


MIDDLE SCHOOL 3RD FLOOR

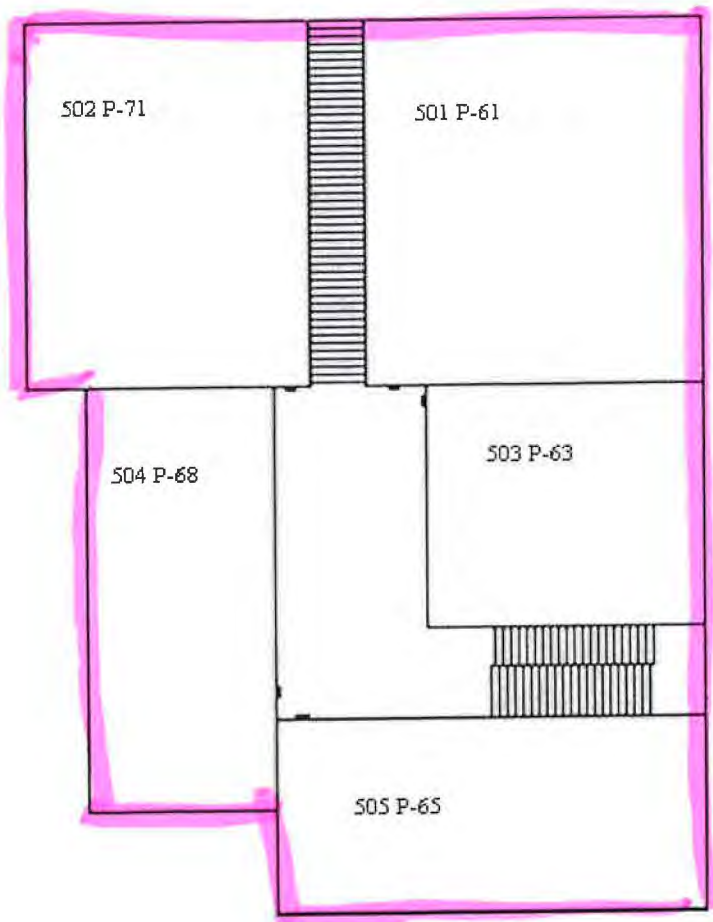

Constructed before 1986

In 1986, the SDWA was amended to ban the use of lead solders which contain more than 0.2% lead. The lead ban provisions of the act became effective in Ohio Plumbing Code on March 30, 1998. The amendments also required the use of lead-free flux, pipes and fittings in new installations and repairs of public water systems, or any plumbing within a residential or nonresidential facility which provides water for human consumption. Lead-free was defined at the time as having no more than 8.0% lead (note this 8.0% was lowered to 0.25% in 2014).


FIRST FLOOR CODE PLAN

1/8" = 1'-0"


PROVIDE 2 ADDITIONAL NEW WALL HANGING
AT THE RECEPTION AND DEPARTMENT OF THE
GOVERNING THE DEPARTMENT INSPECTOR.

1 HOUR FIRE SEPARATION ASSEMBLY W/ 60 MIN
UT DESIGN NOTED, USES AND DOCS
EXISTING 2 HOUR FIREWALL

ROOM NO.	ROOM NAME	SQUARE FOOTAGE	CEILING HEIGHT
A101	CLASSROOM	771	9'-0"
A102	STAIRWELL	182	EXIST.
A103	CLASSROOM	182	EXIST.
A104	CLASSROOM	182	EXIST.
A105	SPECIAL EDUCATION	246	EXIST.
A106	CLASSROOM	246	EXIST.
A107	CLASSROOM	246	EXIST.
A108	CLASSROOM	246	EXIST.
A109	CLASSROOM	246	EXIST.
A110	CLASSROOM	246	EXIST.
A111	CLASSROOM	246	EXIST.
A112	CLASSROOM	246	EXIST.
A113	CLASSROOM	246	EXIST.
A114	CLASSROOM	246	EXIST.
A115	CLASSROOM	246	EXIST.
A116	CLASSROOM	246	EXIST.
A117	CLASSROOM	246	EXIST.
A118	CLASSROOM	246	EXIST.
A119	CLASSROOM	246	EXIST.
A120	CLASSROOM	246	EXIST.
A121	CLASSROOM	246	EXIST.
B101	CLASSROOM	771	9'-0"
B102	STAIRWELL	182	EXIST.
B103	CLASSROOM	182	EXIST.
B104	CLASSROOM	182	EXIST.
B105	SPECIAL EDUCATION	246	EXIST.
B106	CLASSROOM	246	EXIST.
B107	CLASSROOM	246	EXIST.
B108	CLASSROOM	246	EXIST.
B109	CLASSROOM	246	EXIST.
B110	CLASSROOM	246	EXIST.
B111	CLASSROOM	246	EXIST.
B112	CLASSROOM	246	EXIST.
B113	CLASSROOM	246	EXIST.
B114	CLASSROOM	246	EXIST.
B115	CLASSROOM	246	EXIST.
B116	CLASSROOM	246	EXIST.
B117	CLASSROOM	246	EXIST.
B118	CLASSROOM	246	EXIST.
B119	CLASSROOM	246	EXIST.
B120	CLASSROOM	246	EXIST.
B121	CLASSROOM	246	EXIST.
B122	CLASSROOM	246	EXIST.
B201	FAN DECK	519	EXIST.

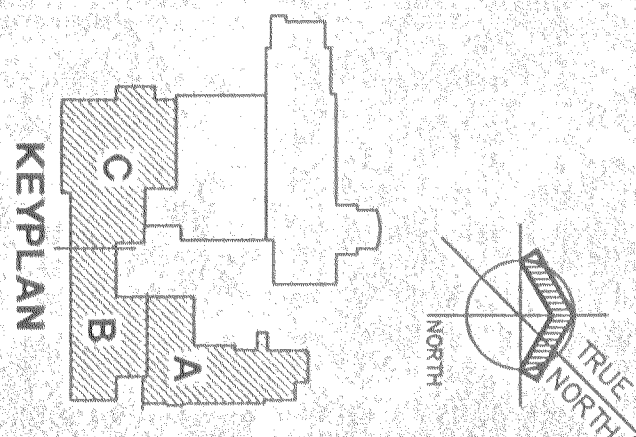


CONVERSION OF
EAST CLINTON HIGH SCHOOL
TO
EAST CLINTON MIDDLE SCHOOL
EAST CLINTON LOCAL SCHOOL DISTRICT
LEES CREEK, OHIO

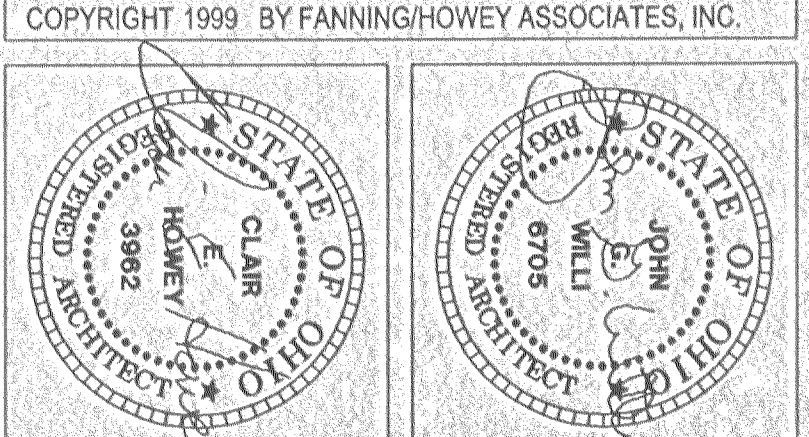


Fanning/Howey
Associates, Inc.
Architects Engineers Consultants

MASTER PLAN/CODE PLAN FIRST FLOOR	
DRAWN BY: SAW	COMM. NO.: 94037.05
CHECKED BY: MSM	DATE: 2/15/99
REVISIONS NO. DATE	
A1.1	

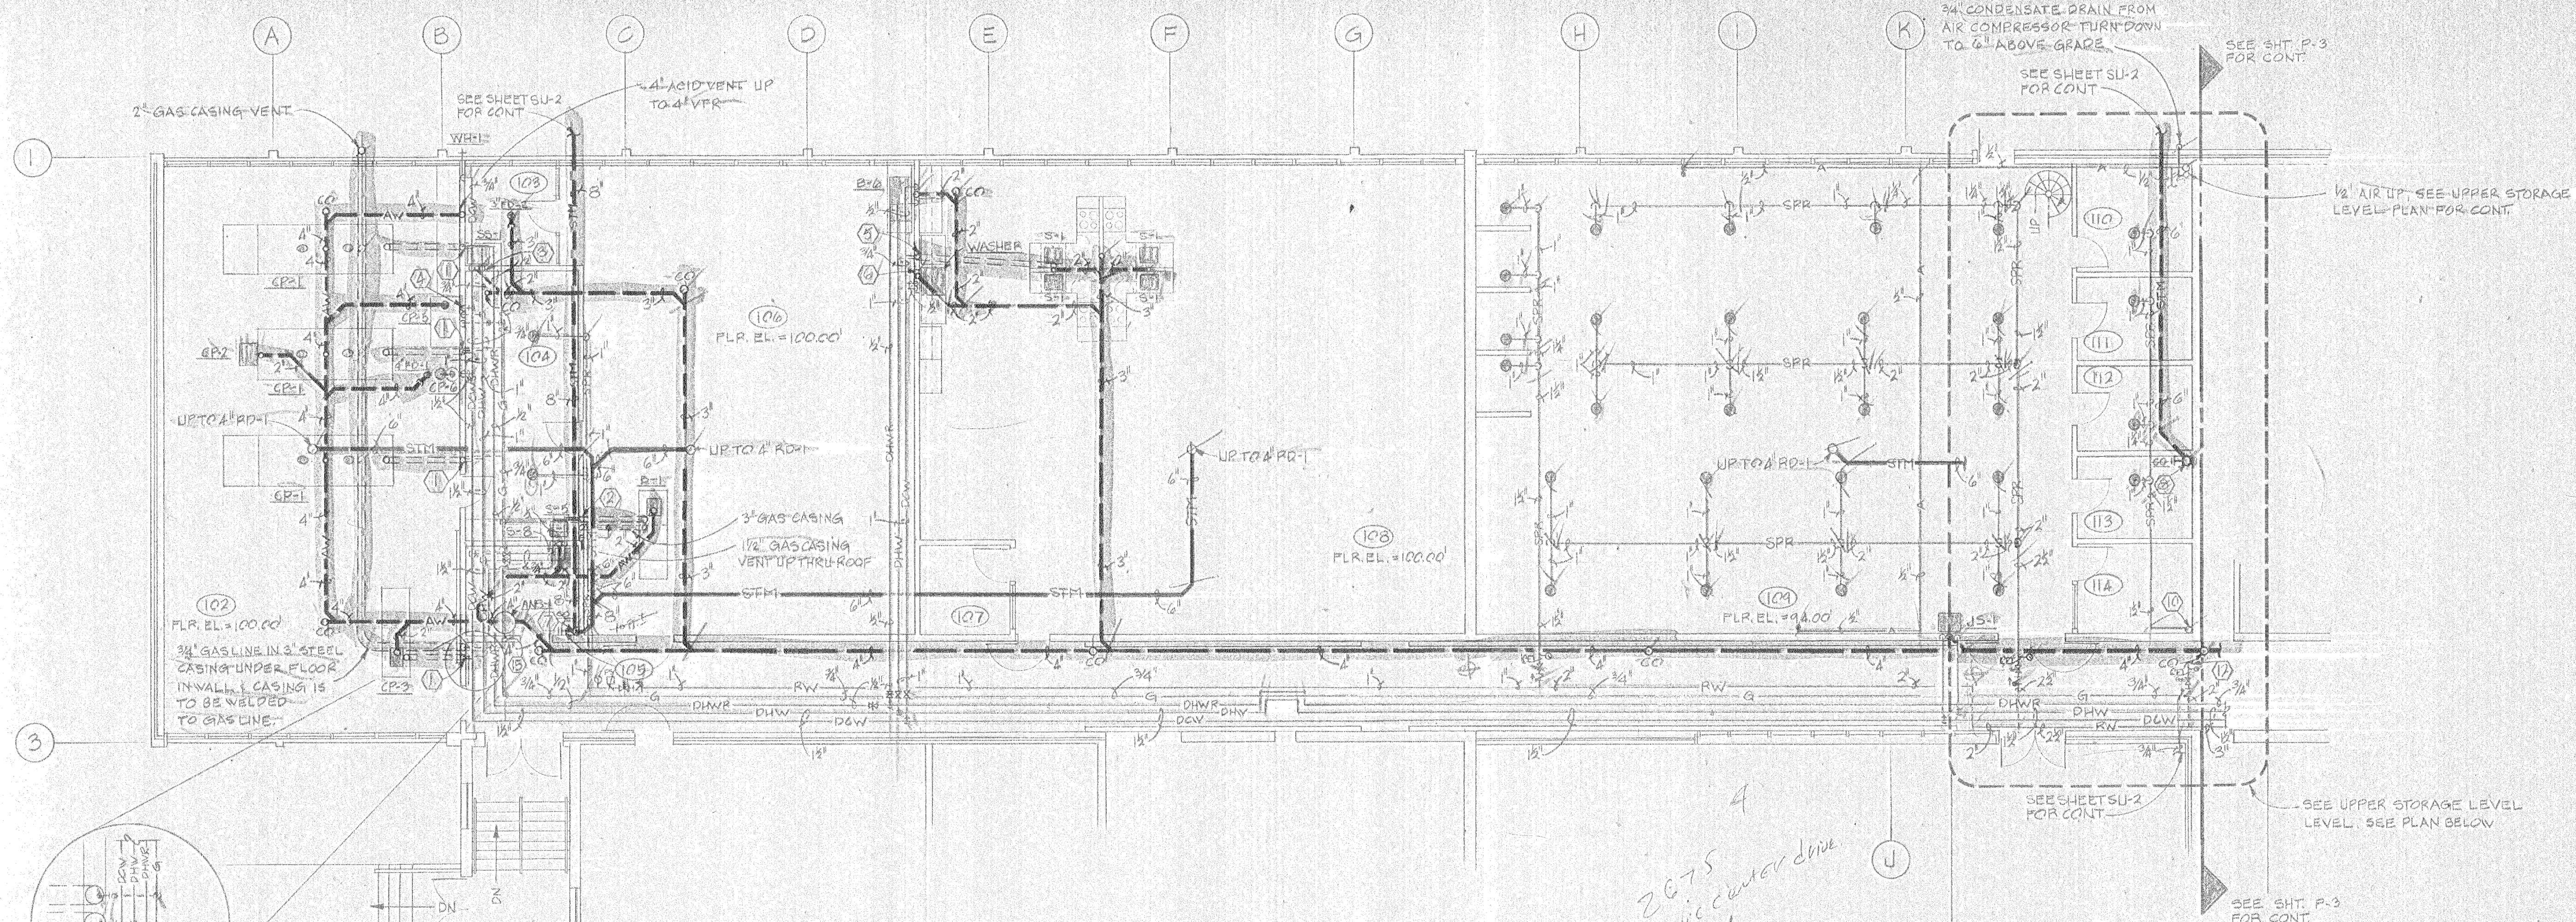


FLOOR PLAN - EAST
- CLASSROOMS
1/8" = 1'-0"

TYP. DETAIL "A"

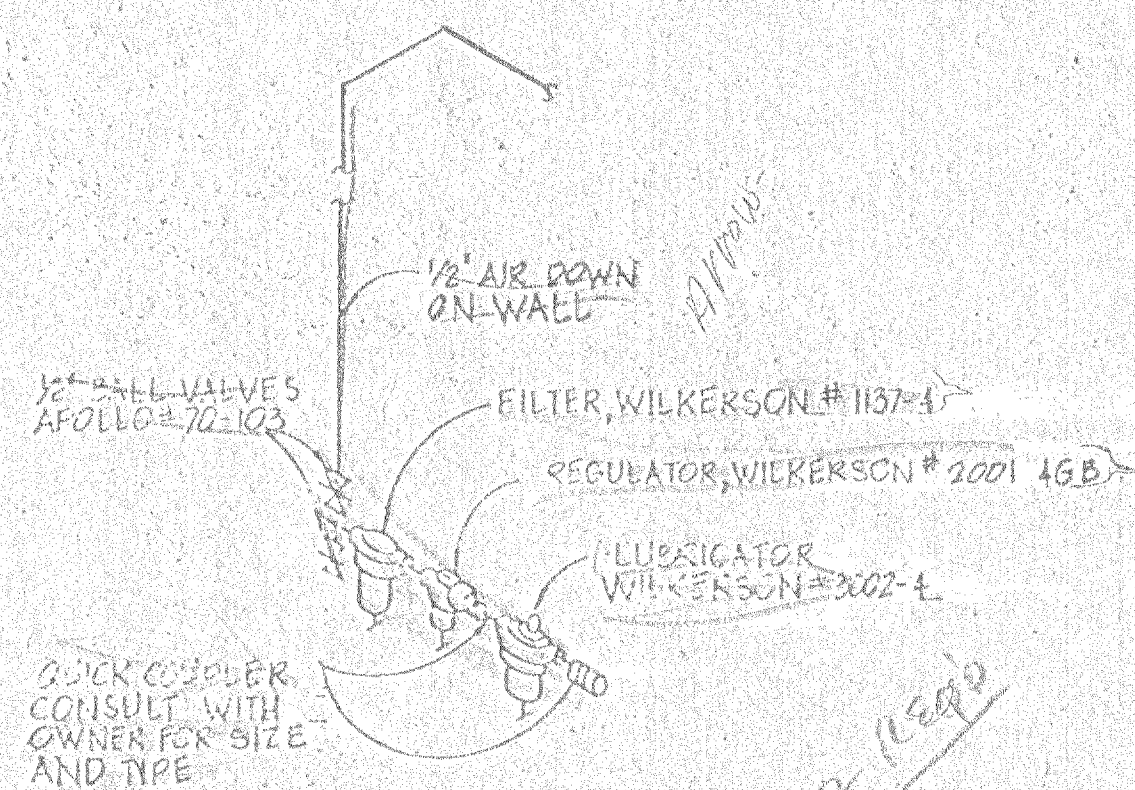


TYPICAL AIR DROP DETAIL
NTS

- CODED NOTES
1. DROP 3/4" DOMESTIC HOT AND COLD WATER LINES IN WALL. RUN IN 6" PVC CONDUIT UNDER FLOOR TO EQUIPMENT AS SHOWN AND CONNECT TO SINKS OR CUP SINKS.
 2. DROP 1/2" DOMESTIC HOT AND COLD WATER LINES IN WALL. RUN IN 6" PVC CONDUIT UNDER FLOOR TO EQUIPMENT AS SHOWN AND CONNECT TO SINKS.
 3. DROP 1/2" DOMESTIC HOT AND COLD WATER LINES IN WALL FOR S-S-T.
 4. DROP 3/4" DOMESTIC COLD AND 1/2" HOT WATER LINES IN WALL TO CP-5.
 5. DROP 3/4" DOMESTIC HOT AND COLD WATER LINES IN WALL. RUN IN 6" PVC CONDUIT UNDER FLOOR TO EQUIPMENT AS SHOWN AND CONNECT TO S-T's.
 6. 1/2" DOMESTIC HOT AND COLD WATER DOWN TO GUY GRAY BOX MODEL NO. FBB-200TS. CONNECT TO 2" STANDPIPE IN WALL.
 7. 8" STORM DOWN.
 8. 6" DOWNSPOUT. SEE UPPER STORAGE LEVEL PLAN THIS SHEET FOR CONTINUATION.
 9. 6" STORM DOWN. SEE PLAN ABOVE FOR CONTINUATION.
 10. 1/4" SPRINKLER LINE UP TO UPPER STORAGE LEVEL. SEE PLAN BELOW FOR CONTINUATION.
 11. 1/4" SPRINKLER LINE DOWN. SEE PLAN ABOVE FOR CONTINUATION.
 12. 2" SPRINKLER LINE. SEE UPPER STORAGE LEVEL PLAN FOR CONTINUATION.
 13. 1" INSULATED TRAP AND CONDENSATE LINE FROM COMPRESSED AIR DRYER.
 14. 1/2" AIR DOWN. SEE PLAN ABOVE FOR CONTINUATION.
 15. 4" ACID VENT FROM ANS-1.
 16. SEE SHEET A-13 FOR EQUIPMENT SCHEDULE. PLUMBING CONTRACTOR TO PROVIDE ROUGH-IN, PIPE, FITTINGS AND FINAL CONNECTION. EQUIPMENT FURNISHED UNDER EQUIPMENT CONTRACT.
 17. SEE SHEET A-14 FOR EQUIPMENT SCHEDULE. PLUMBING CONTRACTOR TO FURNISH AND INSTALL SINKS, FITTINGS, PROVIDE ROUGH-INS AND MAKE FINAL CONNECTIONS.
 18. SEE SHEET A-15 FOR EQUIPMENT SCHEDULE. PLUMBING CONTRACTOR TO PROVIDE ROUGH-IN, PIPE, FITTINGS AND MAKE FINAL CONNECTIONS. EQUIPMENT FURNISHED UNDER EQUIPMENT CONTRACT.

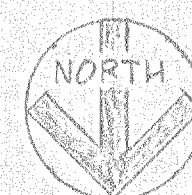


2075
CIVIL CENTER DRIVE
45231

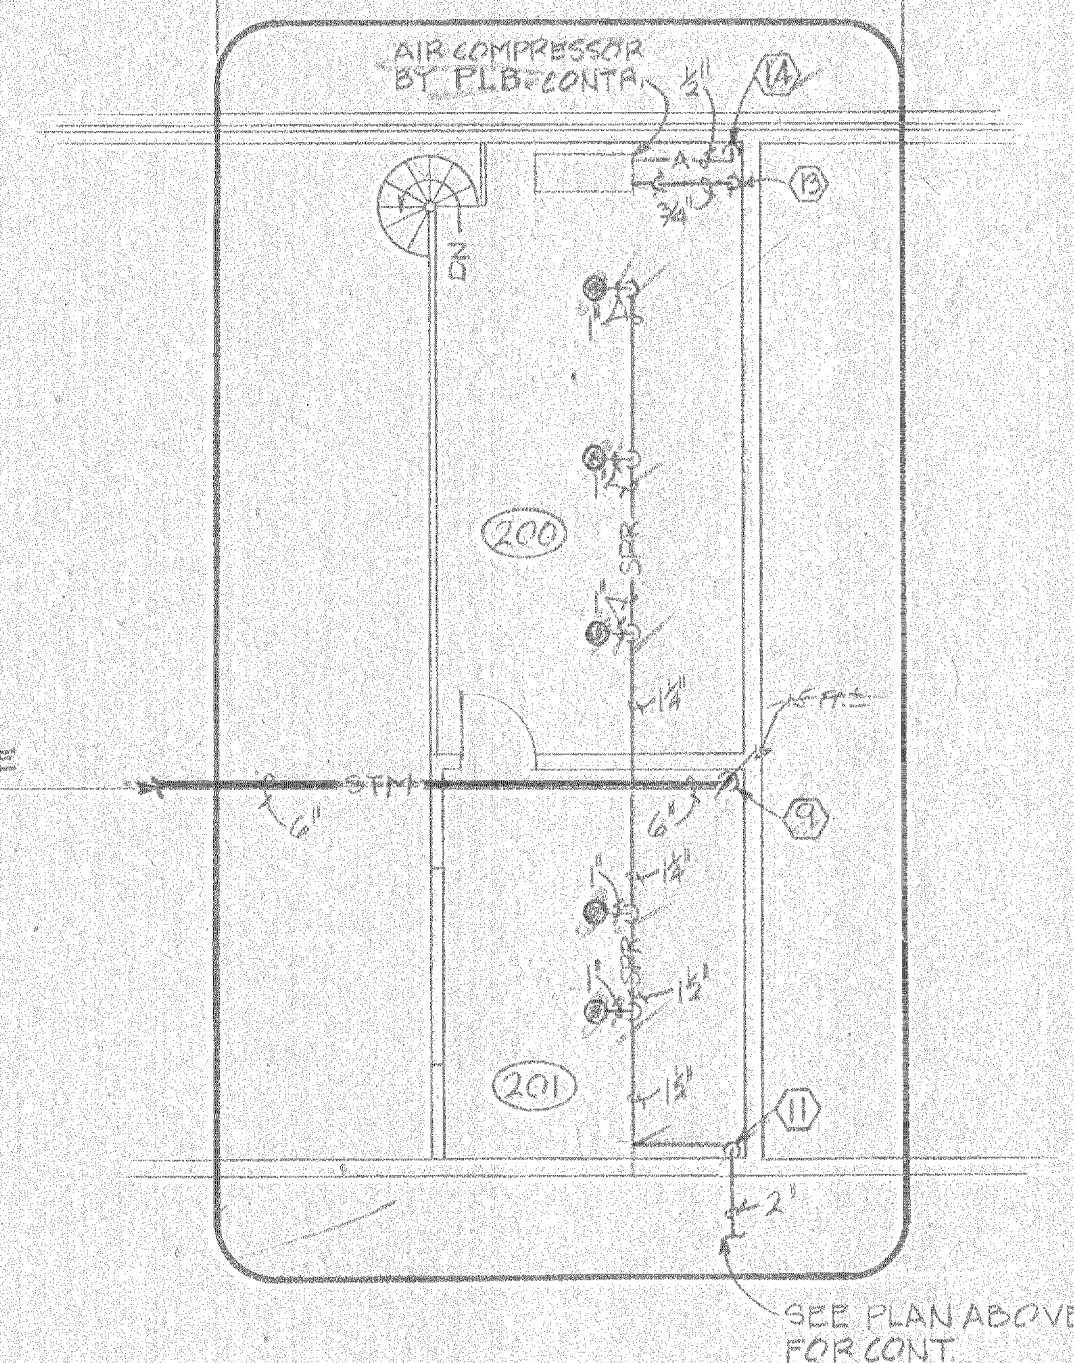

UPPER STORAGE LEVEL
1/8" = 1'-0"

		STALLSMITH, FERNANDEZ ARCHITECTS 24 COMPTON ROAD CINCINNATI, OHIO		Approved:
		REMODELING AND ADDITION TO EAST CLINTON HIGH SCHOOL LEES CREEK, OHIO		
		Revisions:		
Drawn: R.D.F.	Date: 9/30/80	P-2	OF	



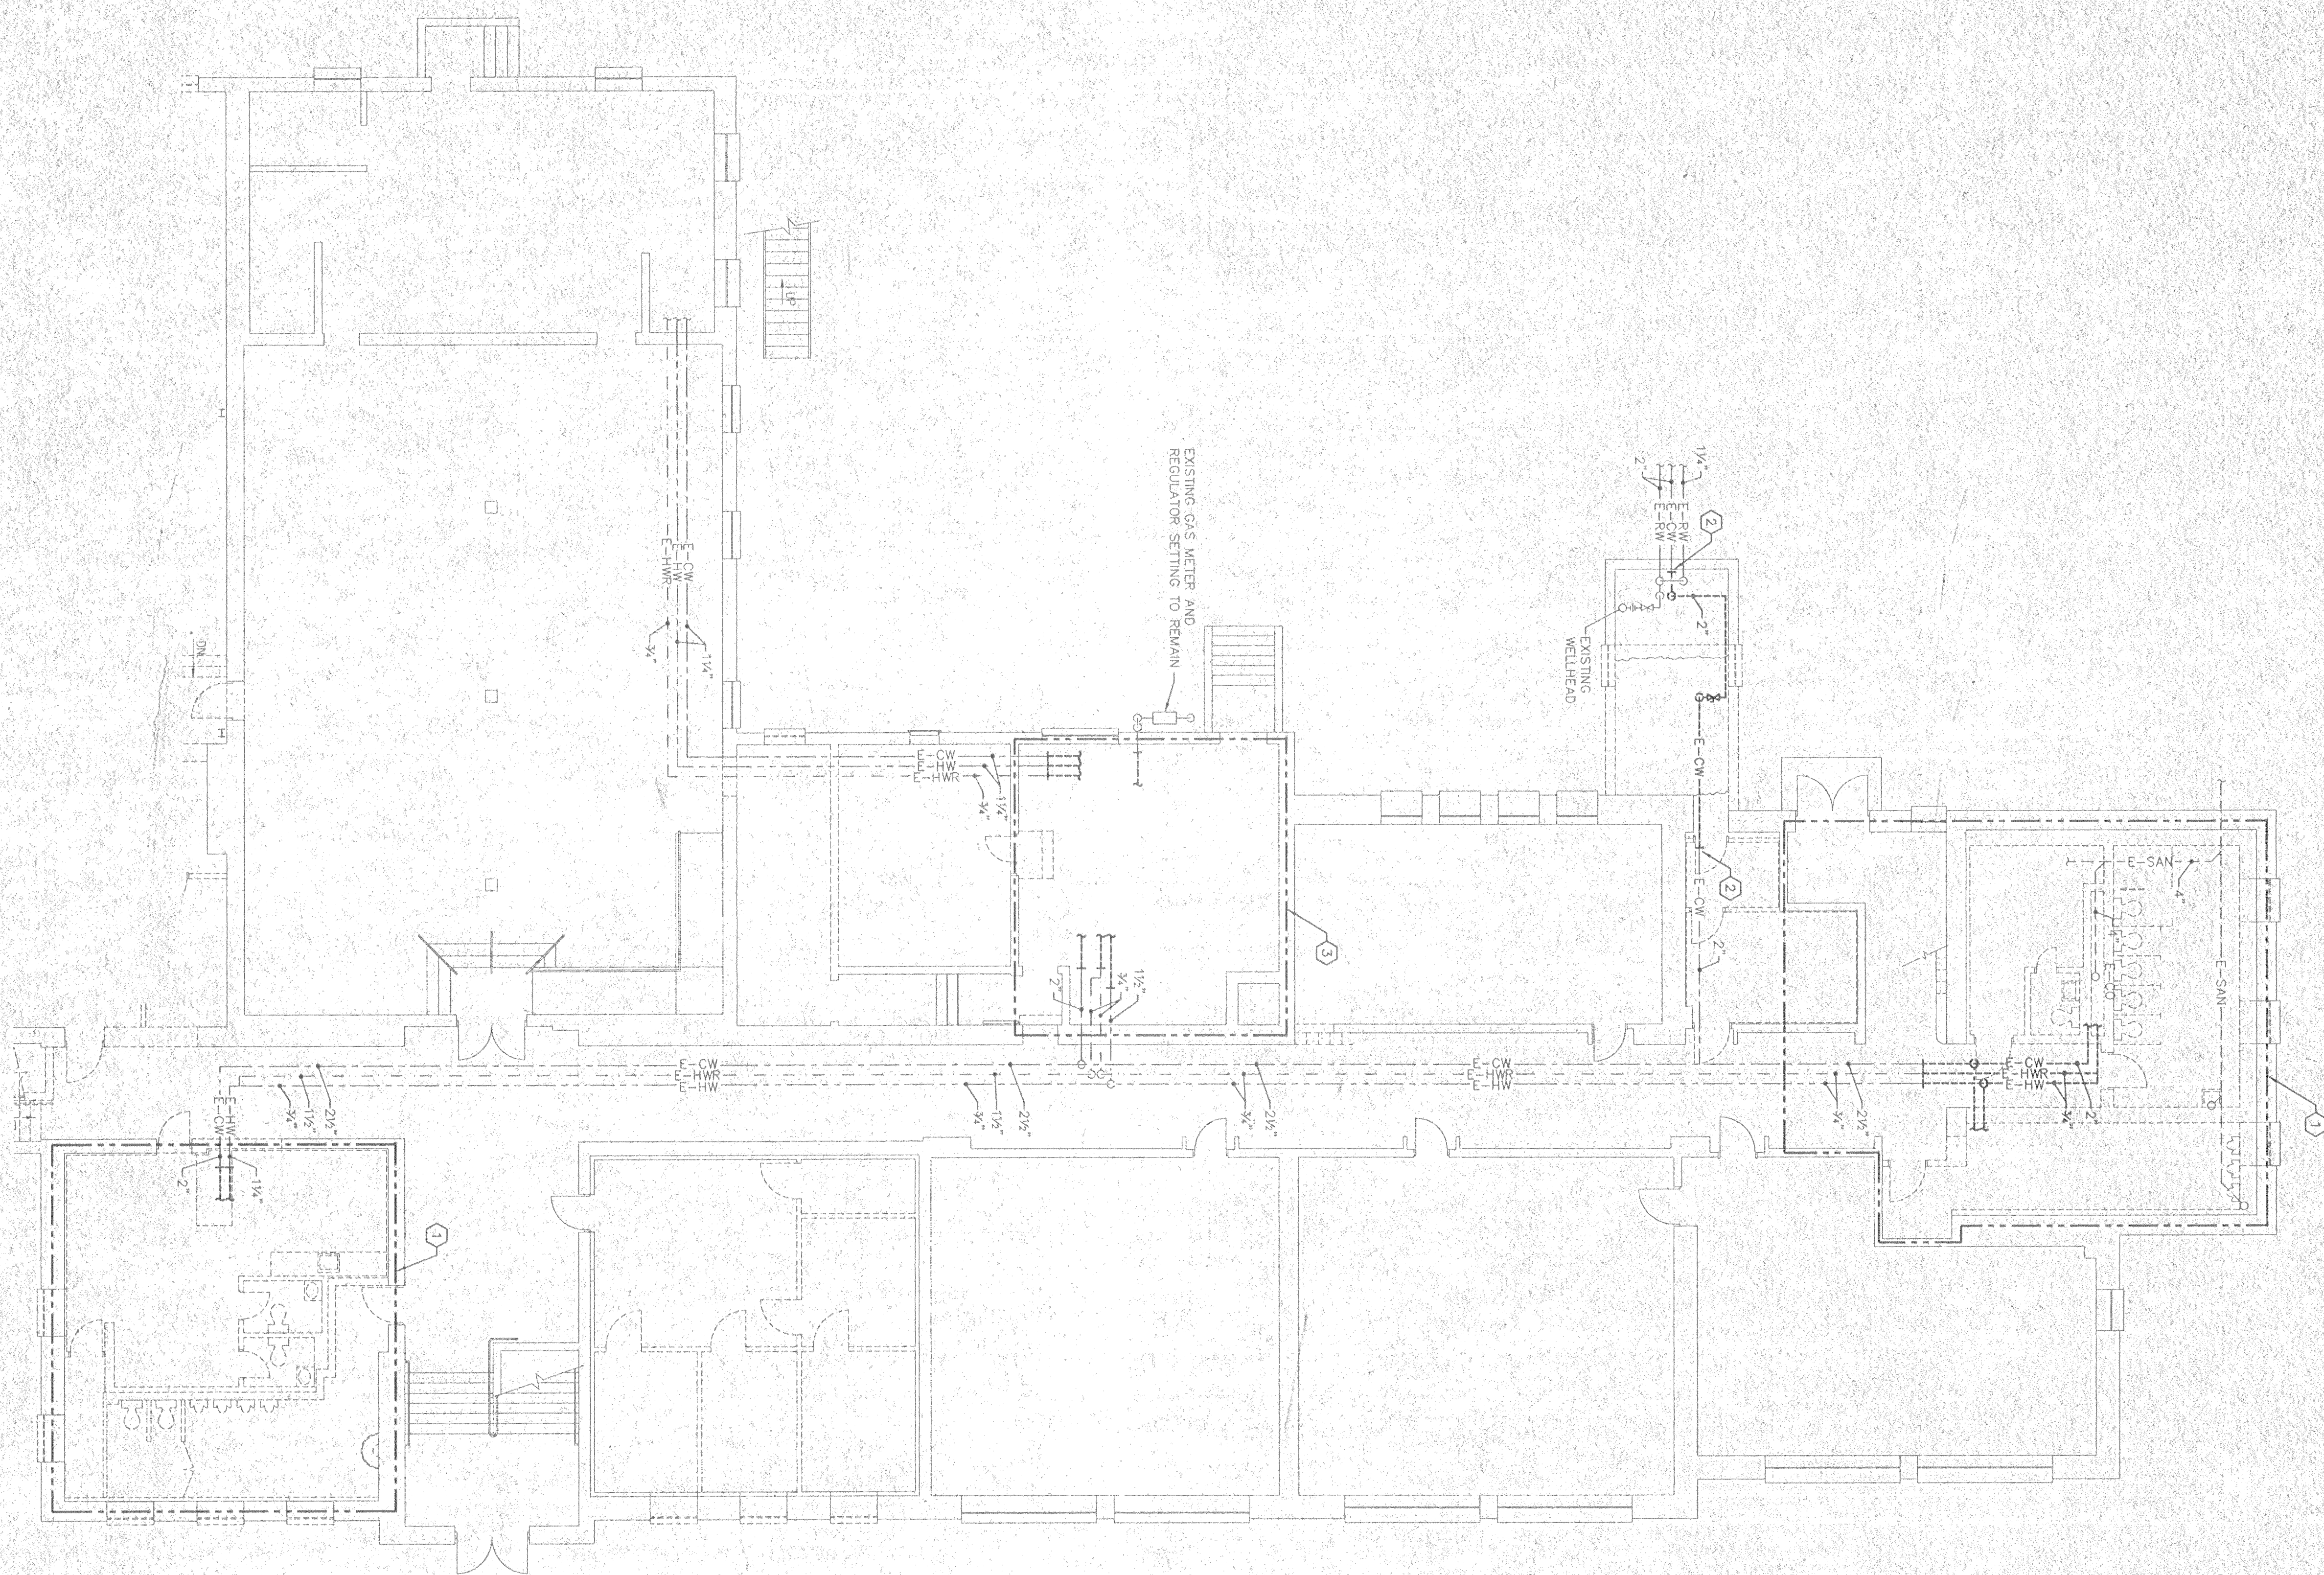


GENERAL DEMOLITION NOTES


1. PLUMBING CONTRACTOR SHALL VISIT THE PROJECT SITE PRIOR TO BIDDING AND VERIFY ANY ADDITIONAL PLUMBING DEMONITION TO BE DONE AT THIS LOCATION THAT WOULD INTERFERE WITH NEW CONSTRUCTION.
2. PLUMBING CONTRACTOR SHALL VERIFY EXIST SIZE AND LOCATION OF ANY EXISTING PLUMBING TO BE DEMONISHED OR REMOVED OR WORK AS DEPENDENT ON THE PLANNING PRIOR TO INSTALLATION.
3. PLUMBING EQUIPMENT, THE PLUMBING CONTRACTOR SHALL PATCH THEM TO MATCH ADJACENT SURFACES.
4. PLUMBING CONTRACTOR SHALL TURN OVER TO THE OWNER OR DISPOSE OF OFF SITE (ACCORDING TO THE OWNER'S WISHES) PLUMBING ITEMS AS SHOWN ON THE DRAWINGS.
5. PLUMBING CONTRACTOR SHALL BE REQUIRED TO COORDINATE EXACT PLUMBING DEMONITION WITH THE ELECTRICAL CONTRACTOR TO AVOID CONFLICTS. PLANS PROVIDE WORK AS REQUIRED.
6. PLUMBING CONTRACTOR SHALL COORDINATE THE SHEET WITH ALL OTHER SHEETS AND SPECIFICATIONS, NOTIFY ARCHITECT OF ANY DISCREPANCIES PRIOR TO INSTALLATION.

KEY NOTES SHEET PD.1


- [illegible]

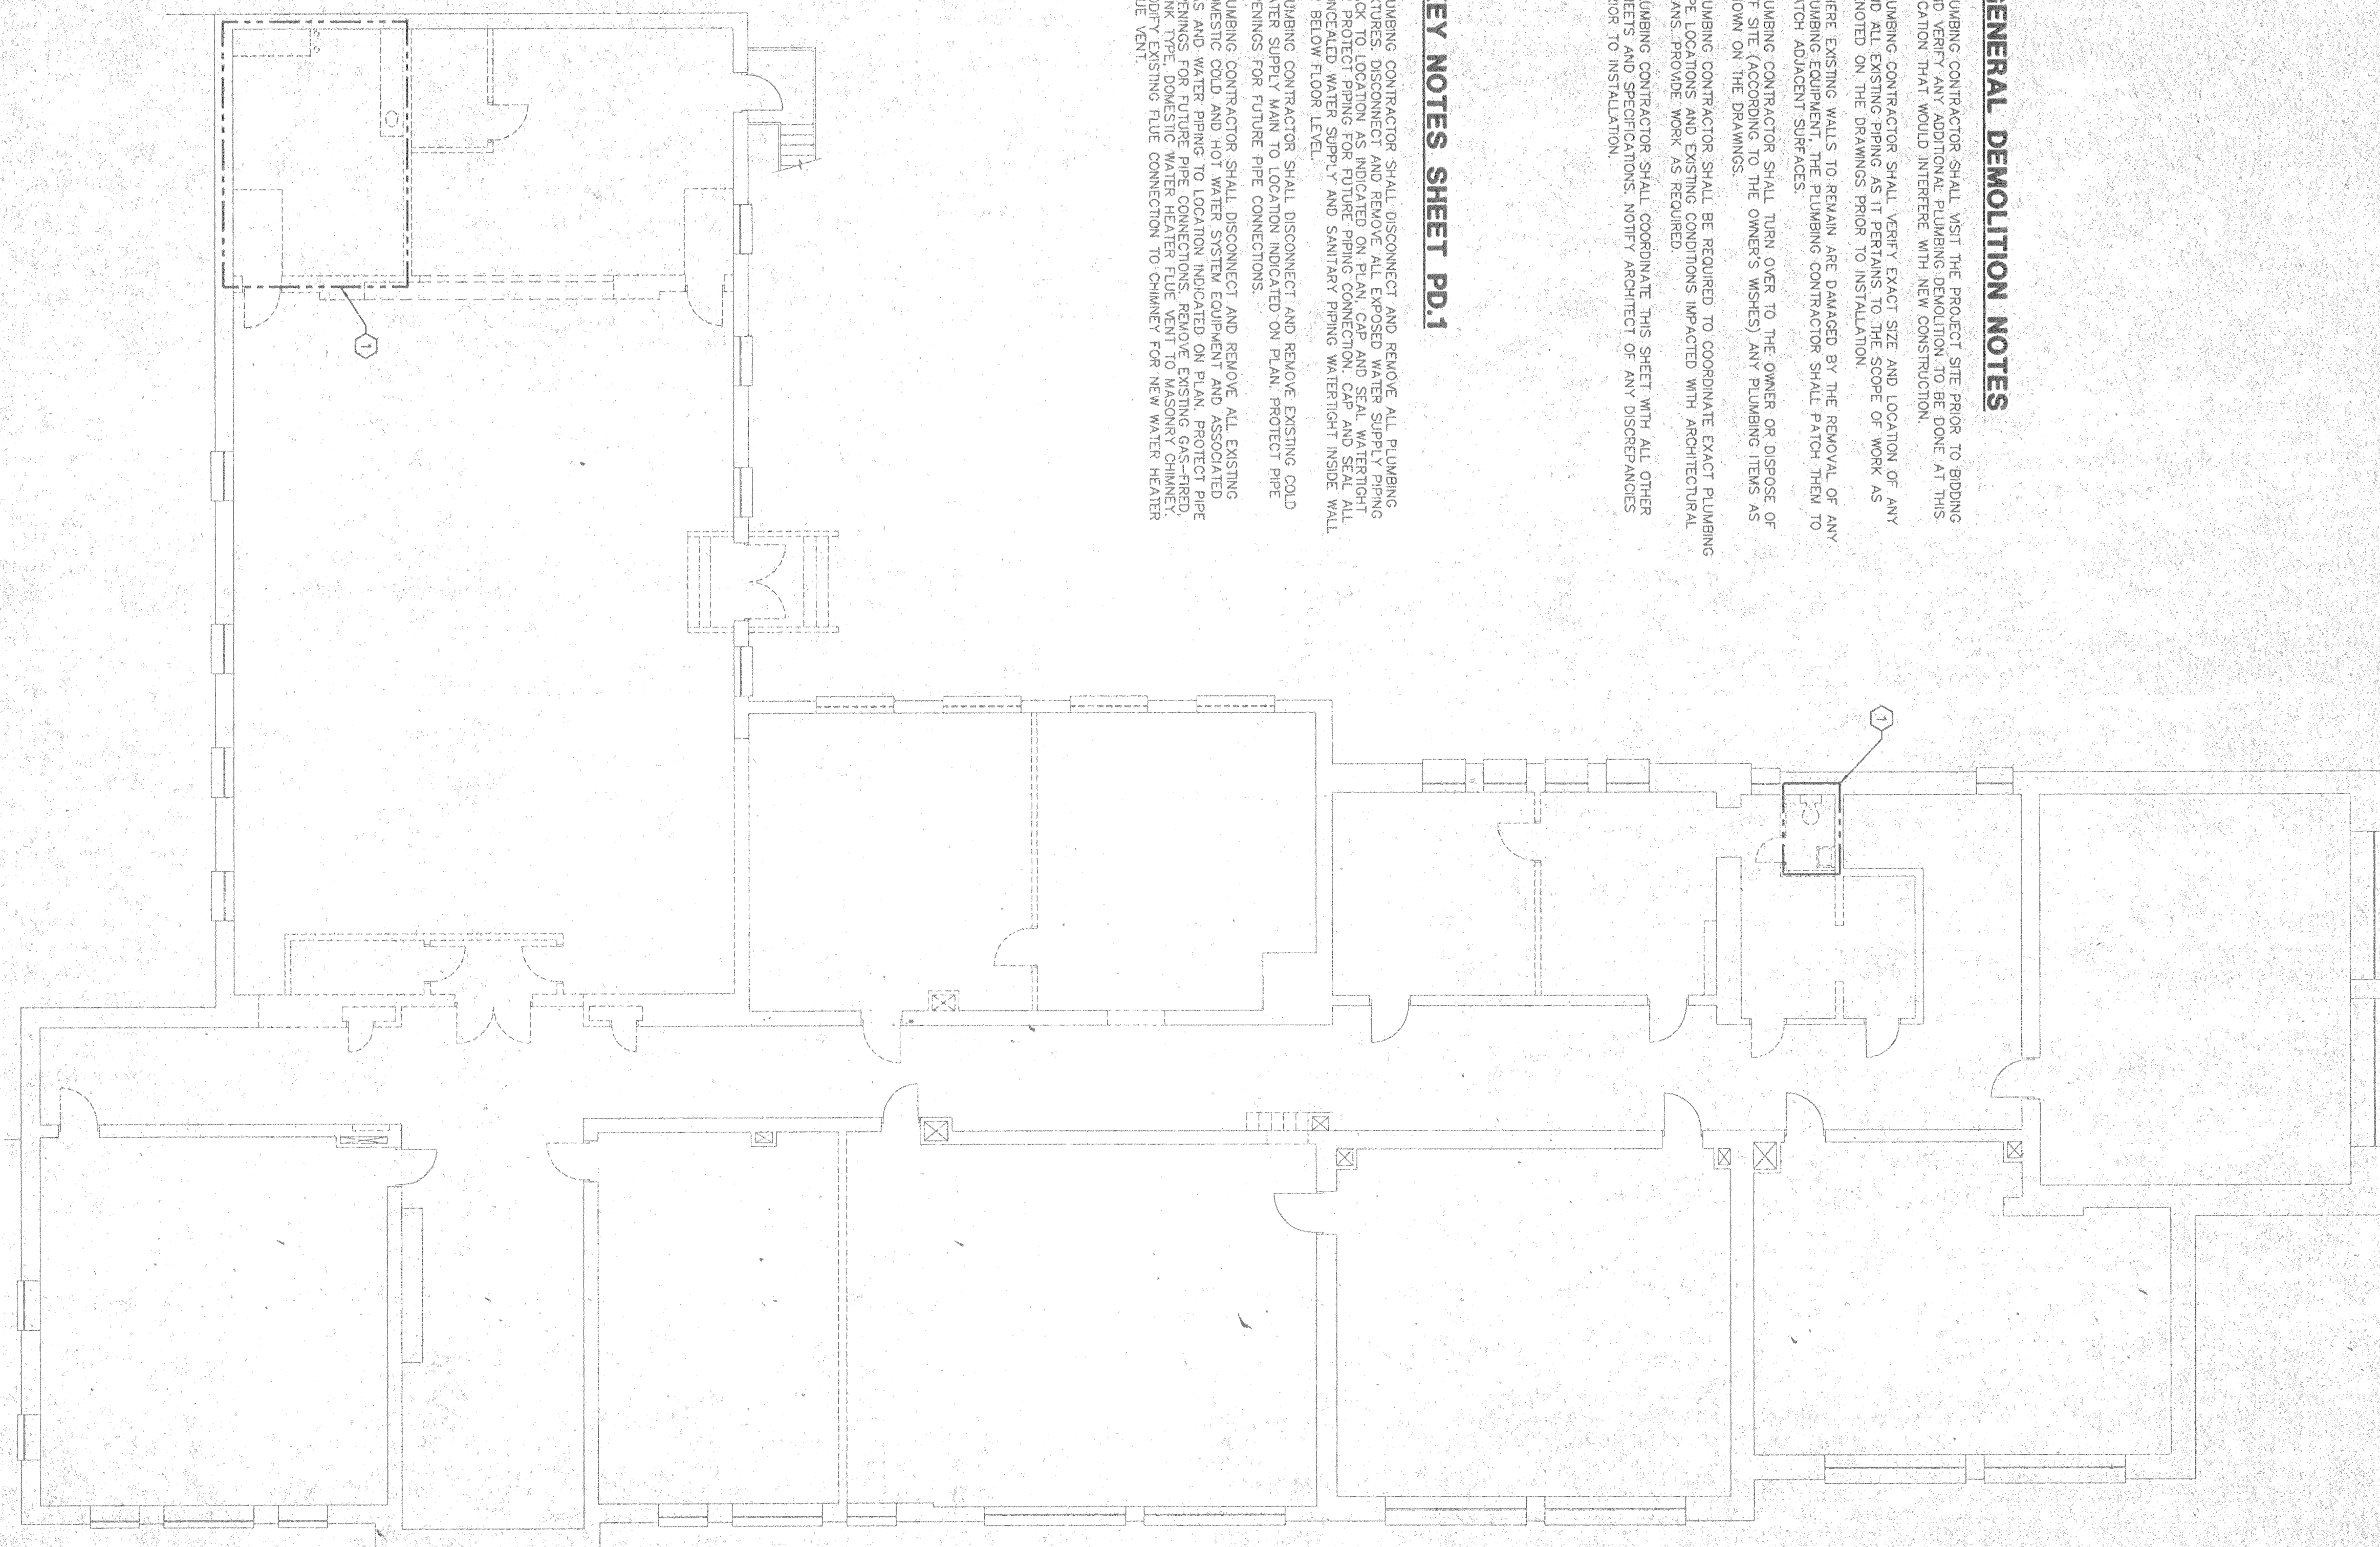

**UNIT A SECOND FLOOR
PLUMBING DEMOLITION PLAN**

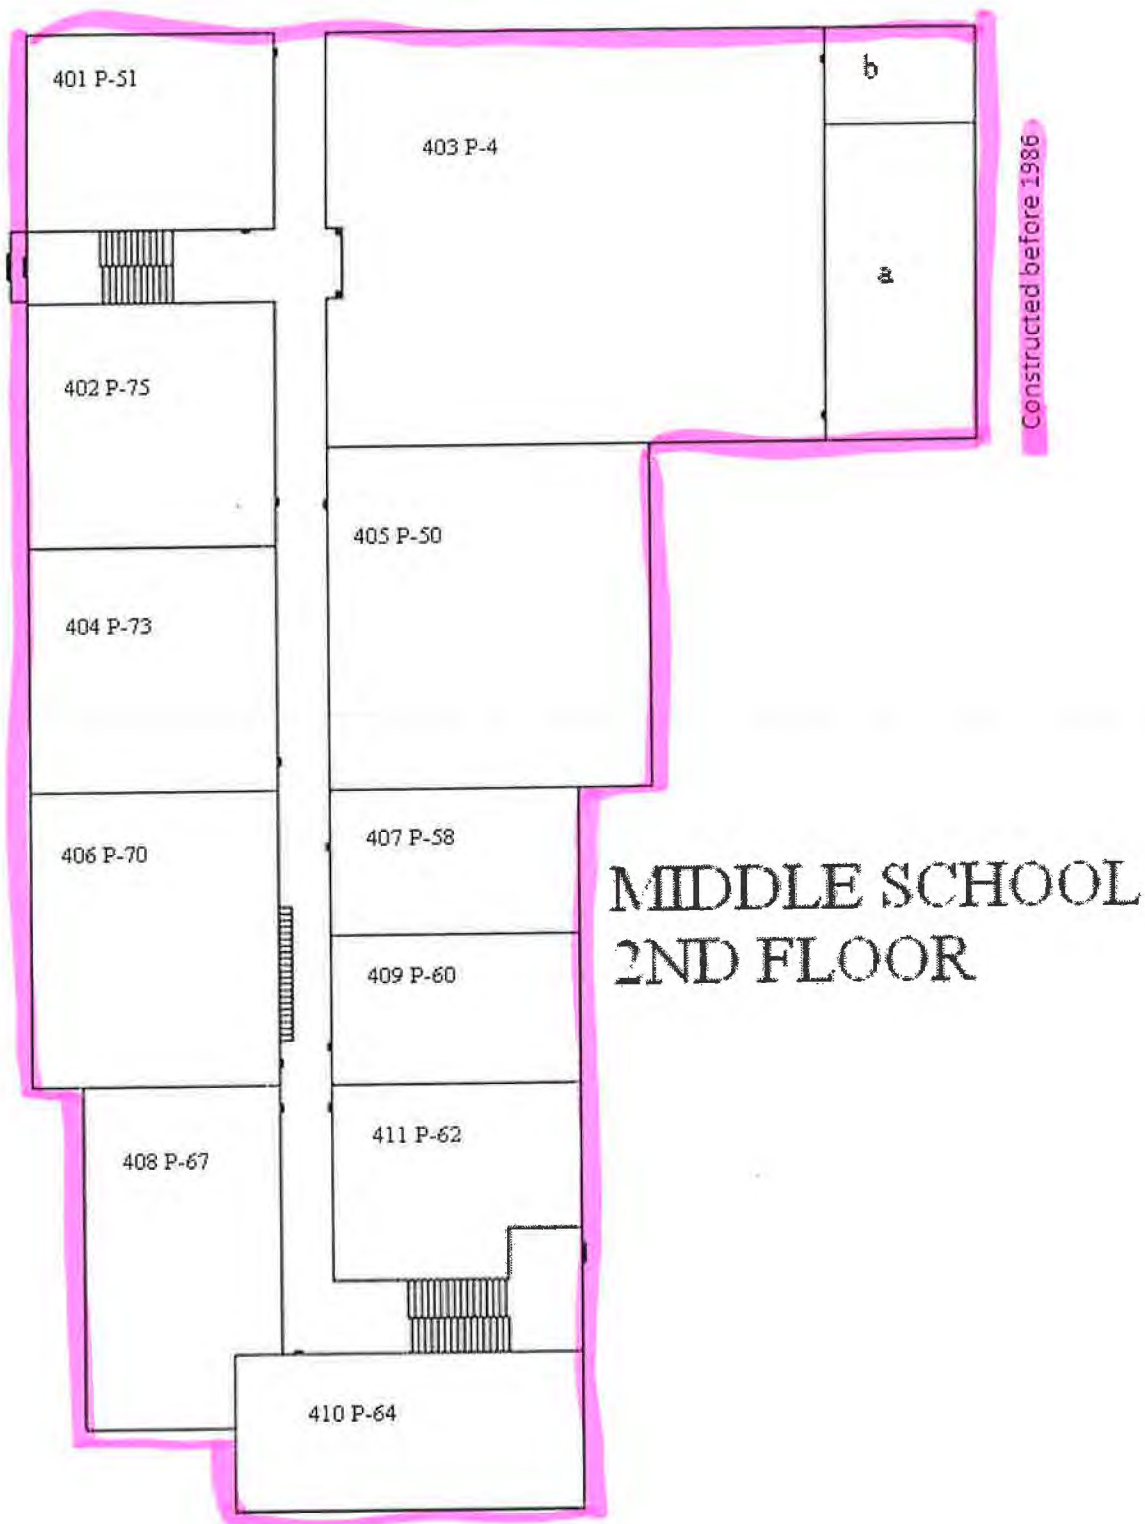


In 1986, the SDWA was amended to ban the use of lead solders which contain more than 0.2% lead. The lead ban provisions of the act became effective in Ohio Plumbing Code on March 30, 1998. The amendments also required the use of lead-free flux, pipes and fittings in new installations and repairs of public water systems, or any plumbing within a residential or nonresidential facility which provides water for human consumption. Lead-free was defined at the time as having no more than 8.0% lead (note this 8.0% was lowered to 0.25% in 2014).

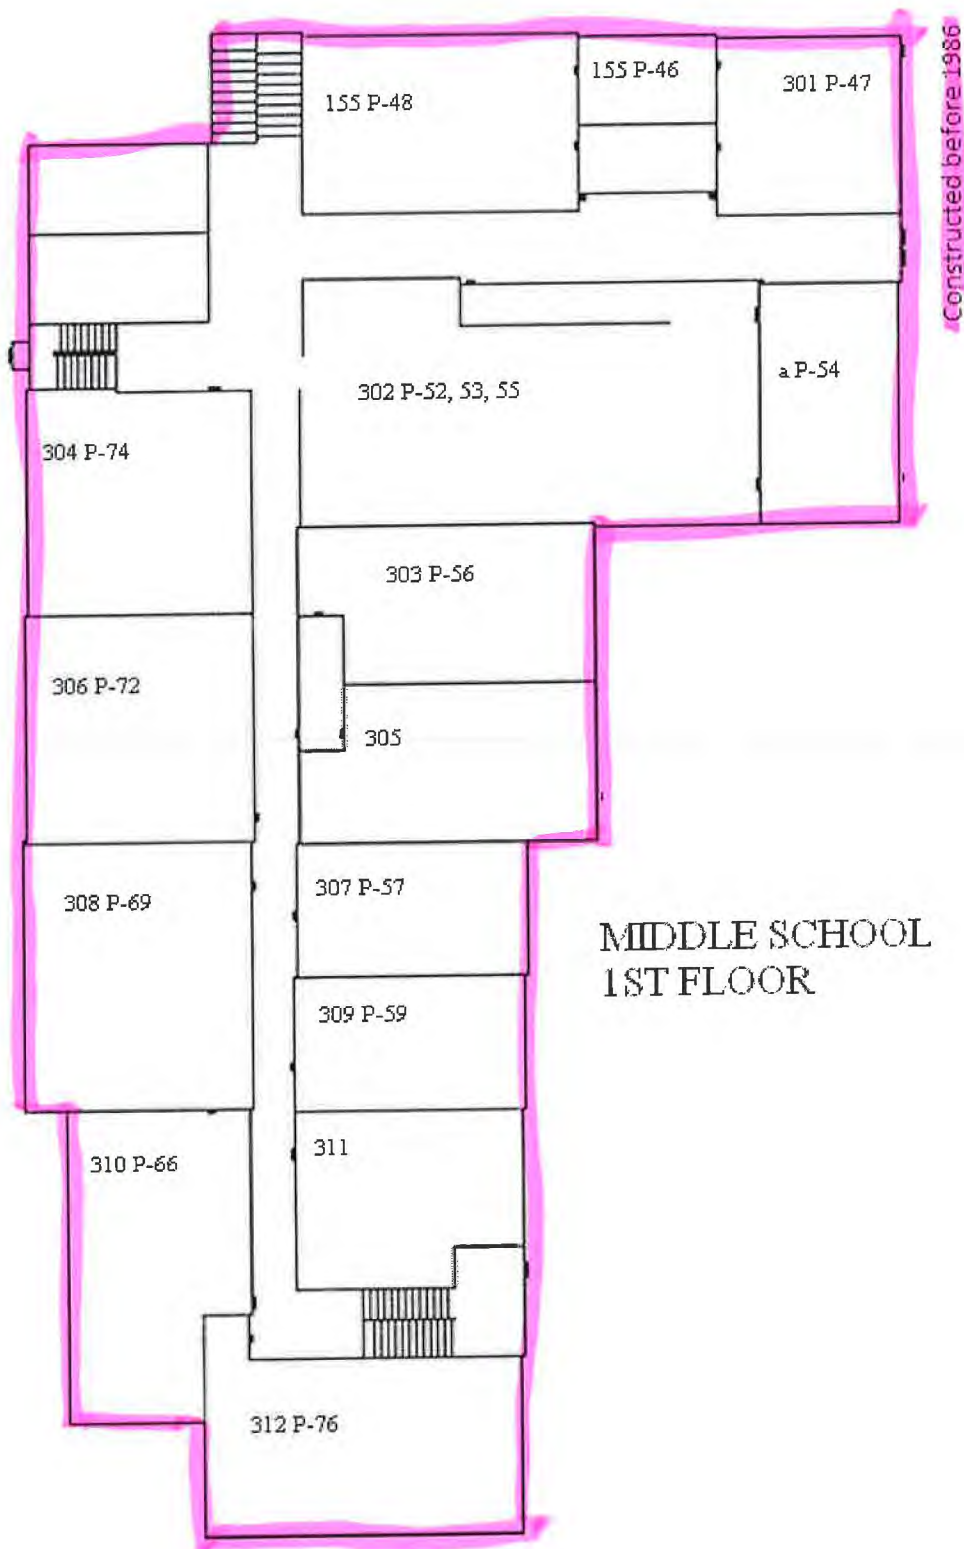

In 1986, the SDWA was amended to ban the use of lead solders which contain more than 0.2% lead. The lead ban provisions of the act became effective in Ohio Plumbing Code on March 30, 1998. The amendments also required the use of lead-free flux, pipes and fittings in new installations and repairs of public water systems, or any plumbing within a residential or nonresidential facility which provides water for human consumption. Lead-free was defined at the time as having no more than 8.0% lead (note this 8.0% was lowered to 0.25% in 2014).

HIGH SCHOOL 2ND FLOOR

Constructed 1999

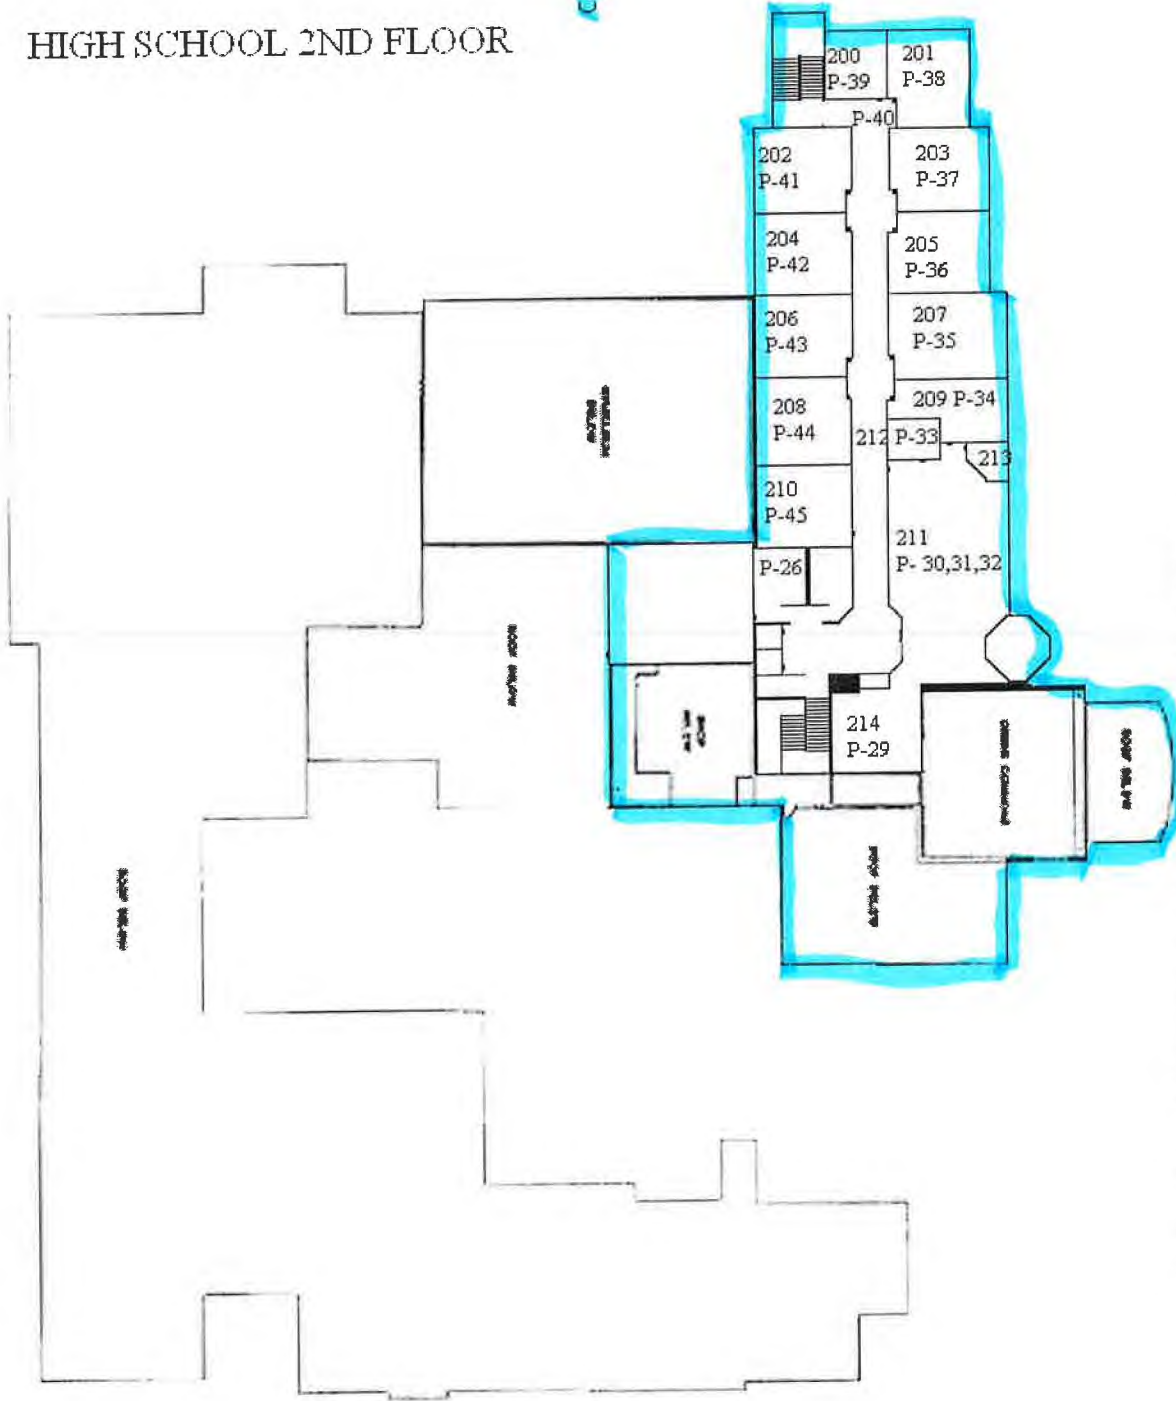


In 1996, the SDWA was further amended to state the following is unlawful:

1. For any person to introduce into commerce any pipe, pipe fitting, plumbing fitting or plumbing fixture, that is not lead free, except for a pipe that is used in manufacturing or industrial processing; or
2. Any person engaged in the business of selling plumbing supplies; except manufacturers, to sell solder or flux that is not lead free; or
3. Any person to introduce into commerce any solder or flux that is not lead free unless the solder or flux bears a prominent label stating that it is illegal to use the solder or flux in the installation or repair of any plumbing providing water for human consumption.

HIGH SCHOOL 1ST FLOOR

Constructed pre 1981
 Constructed 1981
 Constructed 1985
 Constructed 1999

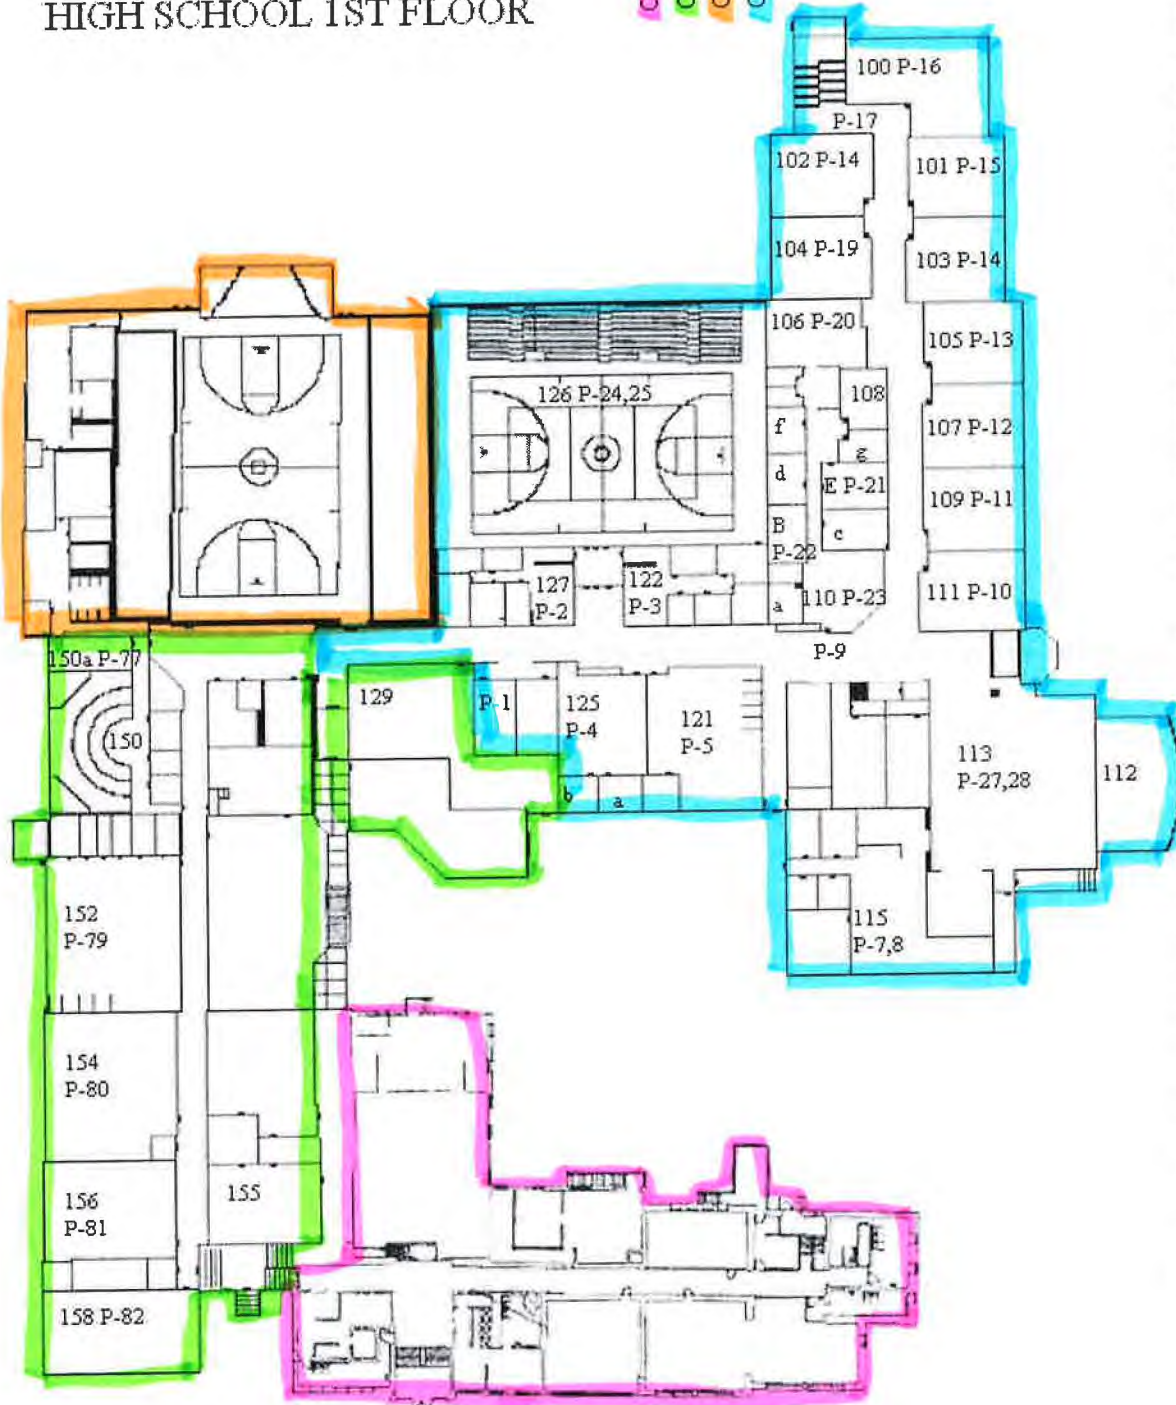

In 1986, the SDWA was amended to ban the use of lead solders which contain more than 0.2% lead. The lead ban provisions of the act became effective in Ohio Plumbing Code on March 30, 1998. The amendments also required the use of lead-free flux, pipes and fittings in new installations and repairs of public water systems, or any plumbing within a residential or nonresidential facility which provides water for human consumption. Lead-free was defined at the time as having no more than 8.0% lead (note this 8.0% was lowered to 0.25% in 2014).