

Mayfield United Methodist Church
7747 Mayfield Road
Chesterland, OH 44026

440-729-4006

Building was constructed after 1998.

All drinking fountains were replaced in 2015
with certified lead free units.

Lead content of all other plumbing fixtures is
not known.


PLAN NOTES

- 1/2" 140°F HW, 3/4" 140°F RHW DN.
 - 1" HW, 1/4" CW UP TO 2ND FLOOR. 1/2" HW, 2" CW, 1/2" RHW, 4" SAN, 2" V DN TO LOWER FLOOR. 1/2" CW TO SERVE (12) WC, (4) U/S. BRANCH TO CONNECTION PER FIXTURE CONNECTION SCHEDULE.
 - 1/2" HW, 3/4" CW DN TO SERVE LAV, WC. BRANCH TO CONNECTION PER FIXTURE CONNECTION SCHEDULE.
 - GAS METER WITH PRESSURE REGULATING VALVE (4375 CFH CONNECTED LOAD; 3875 CFH CURRENT; 500 CFH FUTURE).
 - VALVE AND CAP 2" CW, 1/2" HW, 2" G FOR FUTURE CONNECTIONS IN GYM.
 - 3/4" CW & 3/4" HW DN TO SERVE KITCHEN EQUIPMENT ITEM NO. 7.
- 5 VALVE AND CAP 2" CW, 1/2" HW, 3/4" RHW FOR FUTURE CONNECTIONS IN GYM. CAP 2 1/2" GAS FOR FUTURE CONNECTION (NO VALVE)

GENERAL NOTES

1. CONNECT GAS PIPING TO EQUIPMENT WITH SHUT-OFF VALVE, DIRT LEG AND UNION.

5 PROVIDE TRAP PRIMER FOR ALL FD'S & FS.

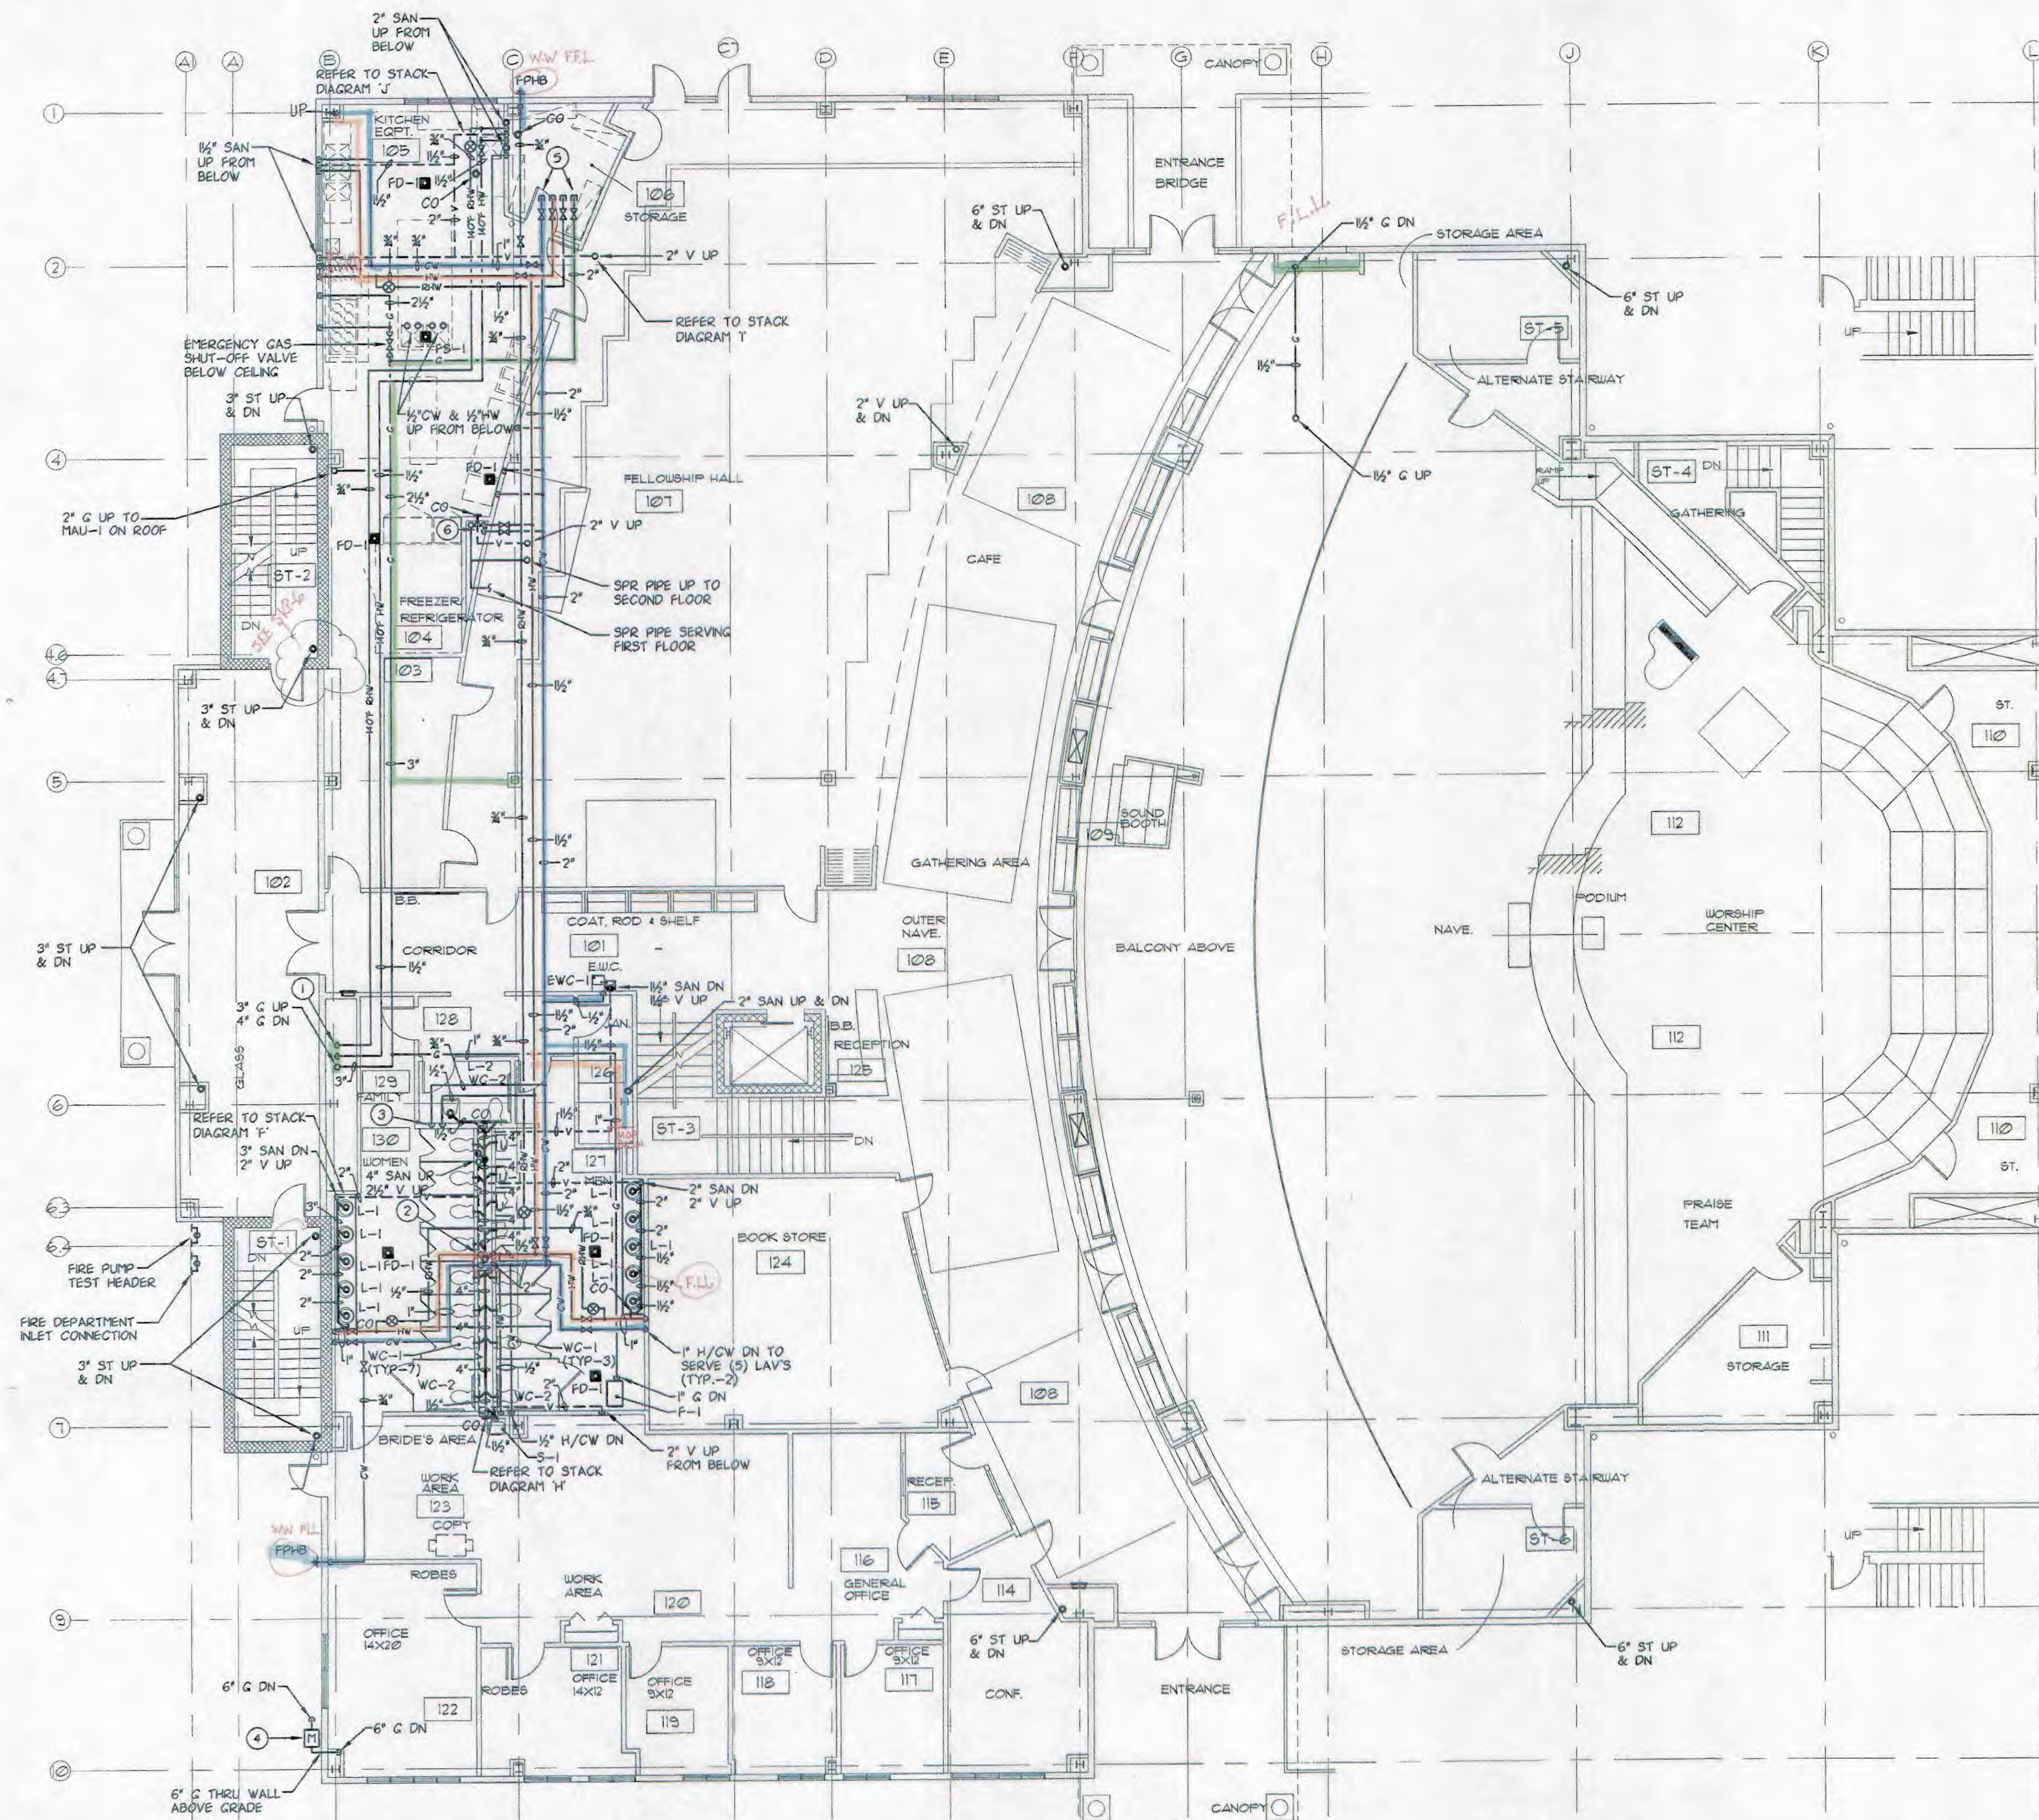

FIRST LEVEL PLUMBING PLAN

SCALE: 1/8" = 1'-0"



FIRST FLOOR PLUMBING PLAN 08-27-01
DATE

NEW CHURCH FOR:
MAYFIELD UNITED METHODIST CHURCH
810 SOM CENTER RD.
MAYFIELD VILLAGE, OHIO 44143

P1.1


OF 5

SAVED AS:

PLOT DATE 1

PROJECT

PROJECT

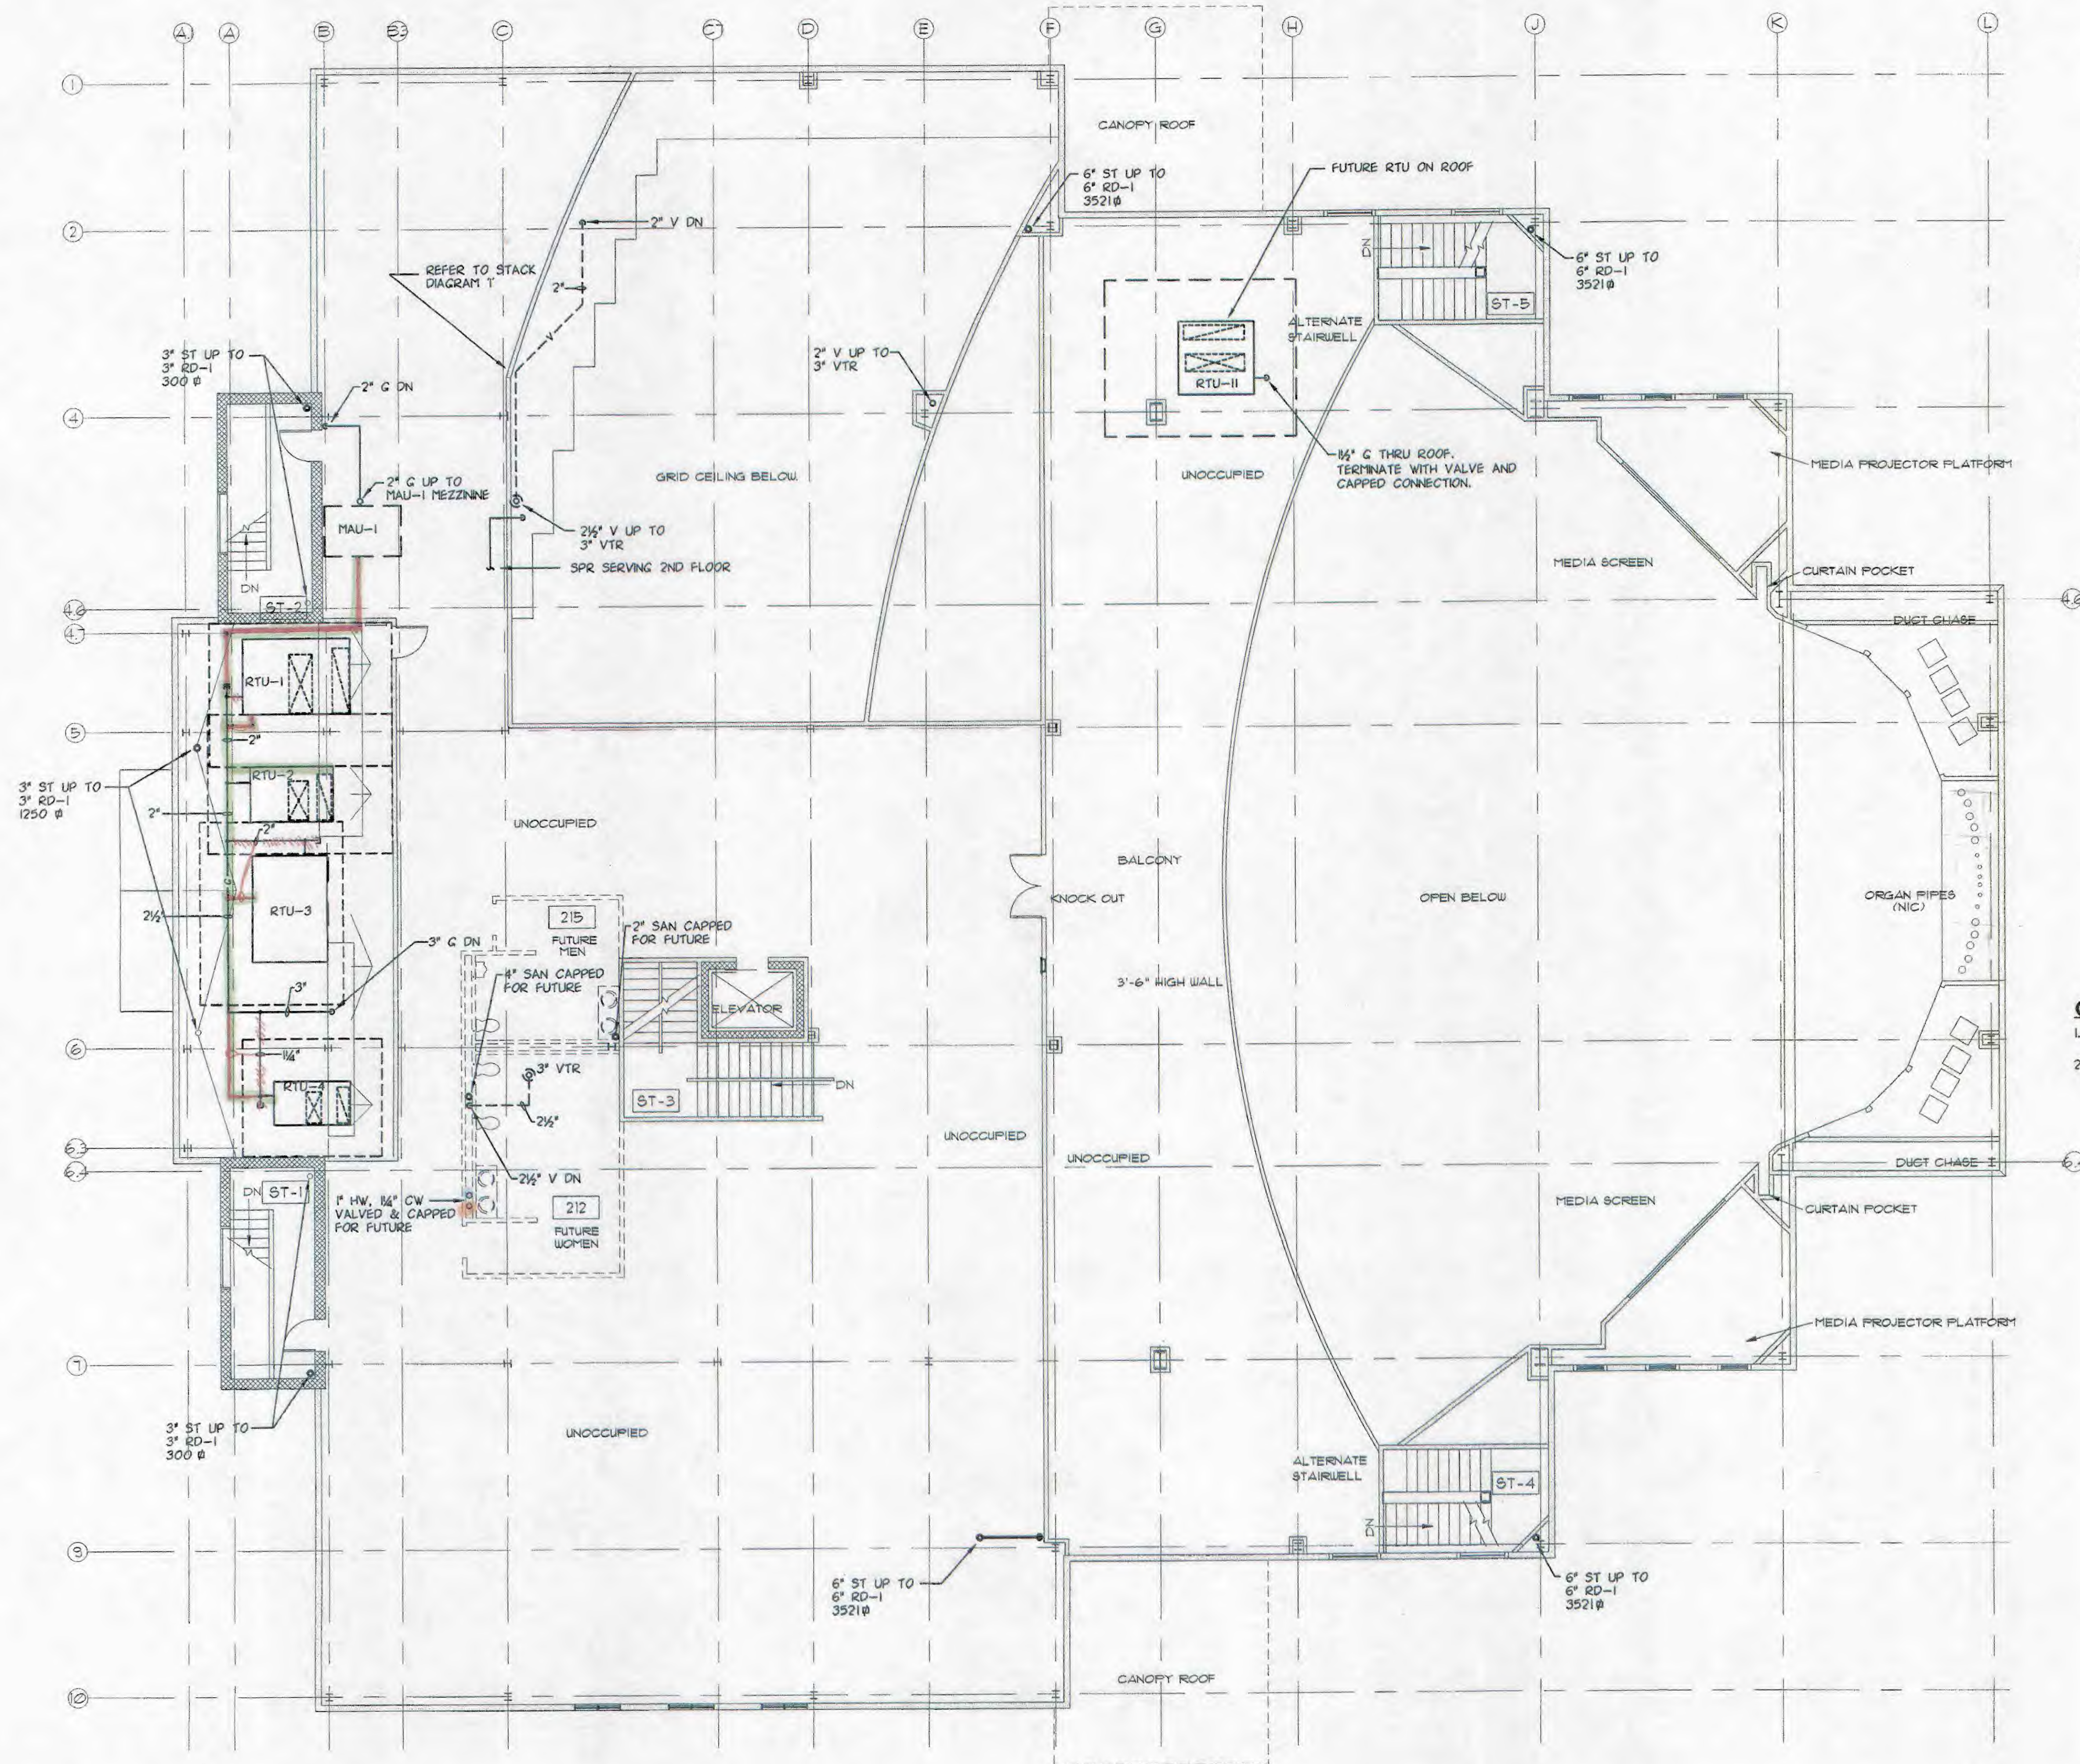

Mayfield United Methodist Church
 7747 Mayfield Road
 Chesterland, OH 44026

440-729-4006

Building was constructed after 1998.

All drinking fountains were replaced in 2015
 with certified lead free units.


Lead content of all other plumbing fixtures is
 not known.

GENERAL NOTES

1. CONNECT GAS PIPING TO EQUIPMENT WITH
 SHUT-OFF VALVE, DIRT LEG AND UNION.
2. REFER TO FIRE STOPPING DETAILS ON
 HVAC DRAWINGS.

SECOND LEVEL PLUMBING PLAN

SCALE: 1/8" = 1'-0"

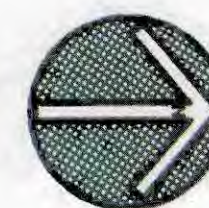

THOMAS J. ZISKA ASSOCIATES ARCHITECTS PLANNERS
 5325 NAIMAN PARKWAY SUITE A CLEVELAND, OHIO 44139 440-349-2517

NOTES:

SAVED AS:

PLOT DATE:

SECOND FLOOR
 PLUMBING PLAN
 DATE: 06-27-01

NEW CHURCH FOR:
 MAYFIELD UNITED METHODIST CHURCH
 810 SOM CENTER RD.
 MAYFIELD VILLAGE, OHIO 44143

P1.2

OF 5