

777 Hollywood Drive, Youngstown Ohio 44515 Herman.stein@pngaming.com

Joshua Bewley,

Our water line construction has reached its 3 year old mark, installed as all new construction and completed September of 2014. Our main underground feed throughout the property is Ductile Iron pipe. As it enters each building it changes to copper. All work was done as "Lead Free Construction" If you should have any further questions please feel free to contact me directly.

Thank You,

Herman Stein

Facilities Manager


330.505.8770


Doc Subtype: Lead Monapor

County: Malania
Secondary ID: (DISCUS)

Secondary ID: <u>の</u>以らり53万/3

Revise #579575 & DOC

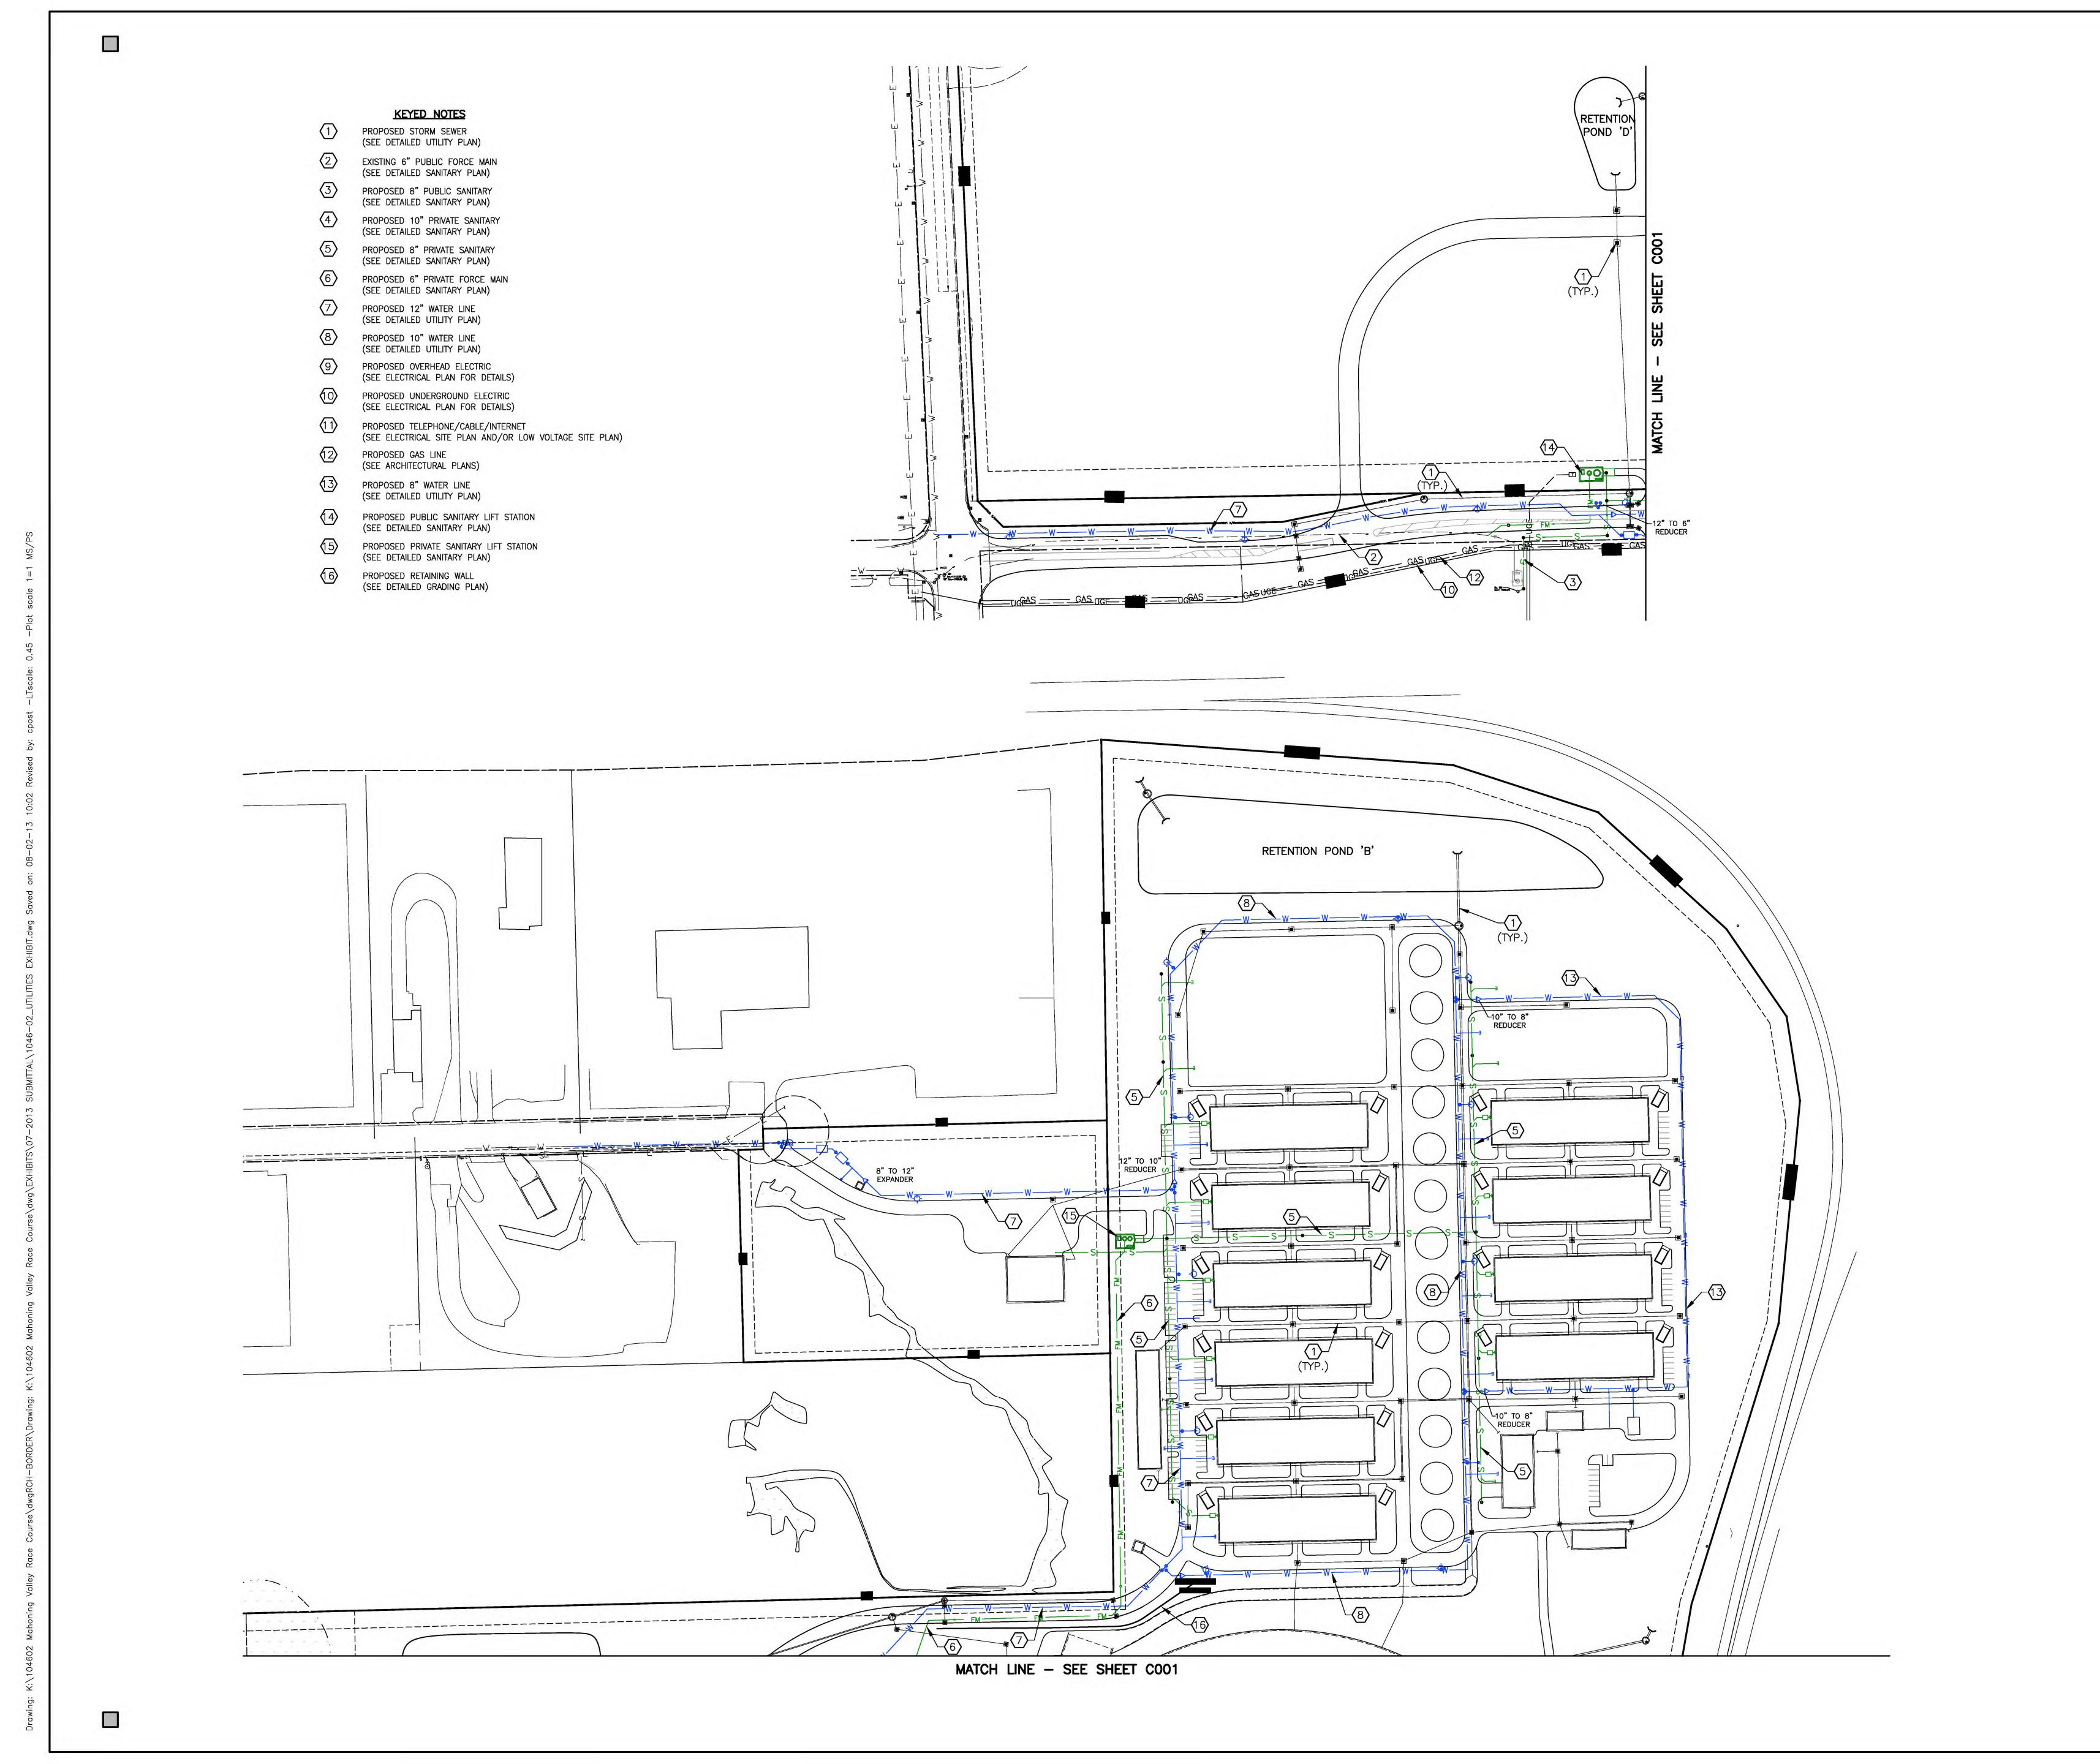

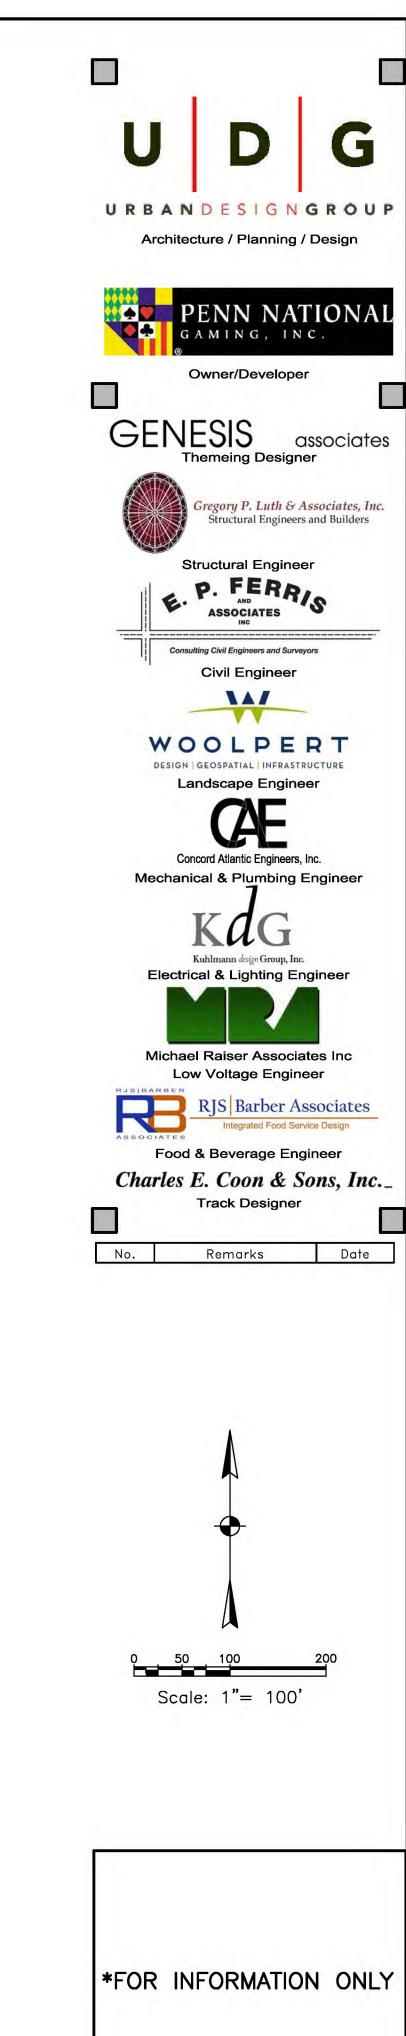

If the empty box below is 2" long then the sheet is full size, if it is 1" long then the sheet is half size, if it is neither then sheet is not to scale.

Austintown Township,

09/12/2013 DATE: SCALE: PROJECT NO. EP Ferris # 1046.002
PROJECT STATUS: Grading and Utility Plan Set
DRAWN BY: CLP CHECKED BY: SWG

OVERALL UTILTIY EXHIBIT

C002

